


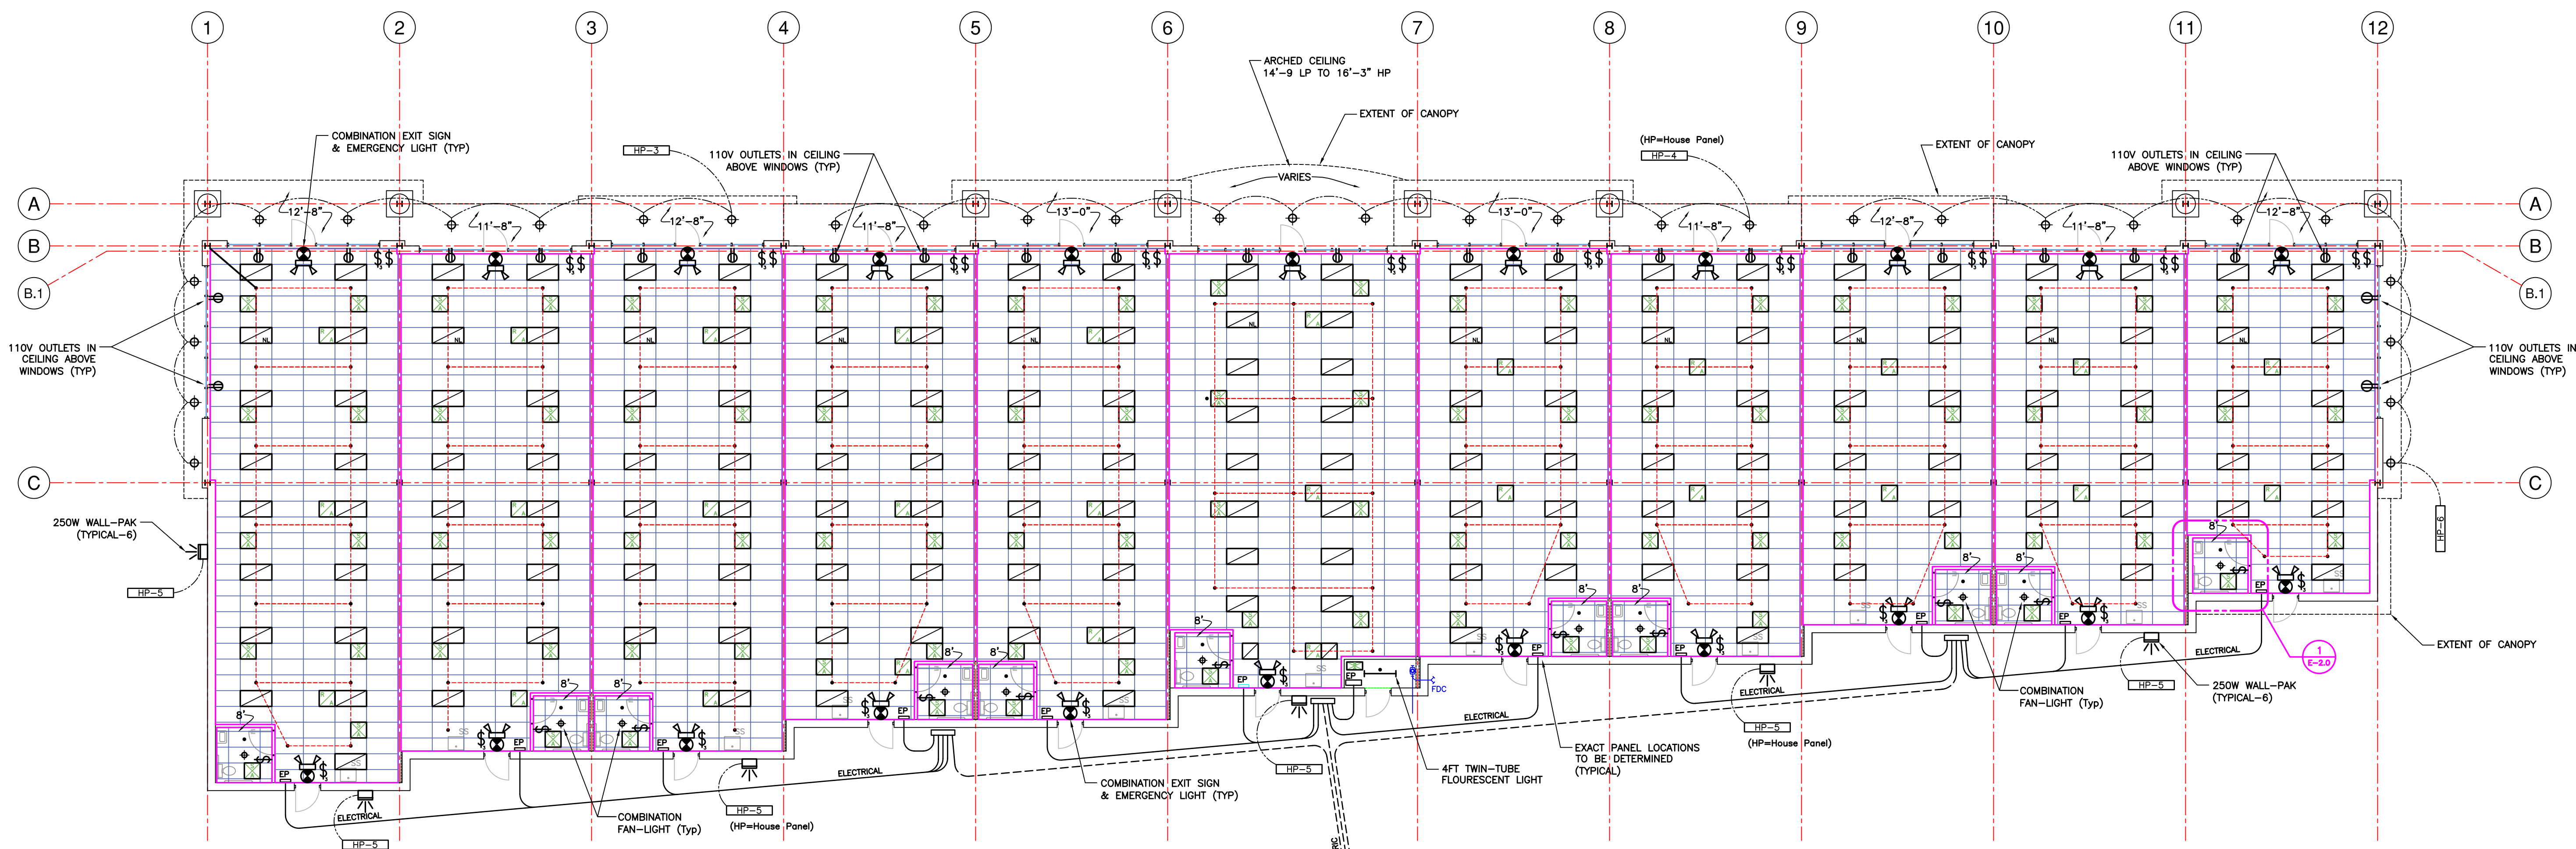


LIGHTING PLAN & RCP

SCALE: 3/32" = 1'-0"

NOTE!
SEE FIRE SUPPRESSION SYSTEM SHOP DRAWINGS
FOR CURRENT LOCATIONS OF SPRINKLER HEADS

NOTE!
ALL WORK SHALL MEET STATE AND LOCAL
BUILDING CODES, REGARDLESS OF WHETHER
SUCH REQUIREMENTS ARE SPECIFICALLY
INDICATED ON THE DRAWINGS.

NOTE!
CEILING GRID @ 10'-0" AFF (UNO)

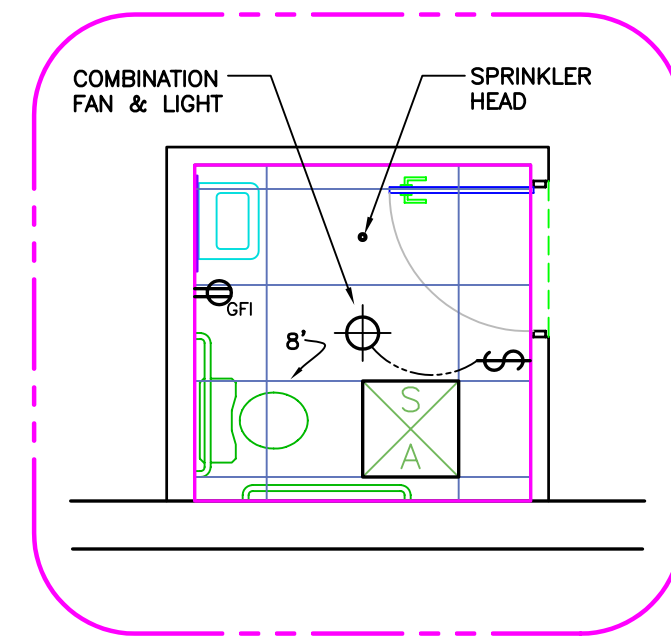

1 TYPICAL LAVATORY
E-2.0 SCALE: 1/4" = 1'-0"

LEGEND	
	RECESSED INCANDESCENT LIGHT FIXTURE
	2'X4' FLUORESCENT LIGHT
	2'X4' FLUORESCENT LIGHT W/PARABOLIC LENS
	2'X4' FLUORESCENT NIGHT LIGHT
	2'X2' FLUORESCENT LIGHT
	2'X2' FLUORESCENT LIGHT W/PARABOLIC LENS
	8'-0" FLUORESCENT LIGHT FIXTURE
	RETURN AIR GRILLE
	SUPPLY AIR DIFFUSER
	LAVATORY EXHAUST FAN
	EXTERIOR LIGHT
	EXIT SIGN
	EMERGENCY LIGHT
	LIGHT SWITCH
	110v. ELECTRICAL OUTLET
	FAN MOTOR
	O.H. DOOR MOTOR
	VOICE JACK
	DATA JACK
	SPRINKLER HEAD

PLEASE NOTE:

THIS DRAWING IS DIAGRAMMATIC AND SHOULD BE USED TO
DETERMINE THE DESIGN INTENT. THE CONTRACTOR SHALL
FIELD VERIFY ALL WORK AND SHALL NOTIFY THE DESIGNER
IMMEDIATELY OF ANY DISCREPANCIES IN THE DOCUMENTS
BEFORE PROCEEDING. FAILURE TO DO SO WILL RESULT
IN THE CONTRACTOR TAKING ALL RESPONSIBILITY AND
LIABILITY IN SAID DISCREPANCIES.

A R Decker & Associates
Consulting Engineers
Civil - Structural
906 East Long Lake Road
Troy, Michigan 48068
Telephone (248) 528-3779
Facsimile (248) 528-3548

RICHARD E. BURGETT
ODESSA BUILDERS, INC.
45000 River Ridge Dr., Suite 200
Clinton Township, MI 48038
Phone: (586) 416-4500
Fax: (586) 226-5666

ENTERPRISE SQUARE
(Enterprise Square @ Hall)
Hall Road (M-59) at Enterprise Drive
Clinton Township, MI 48038

LIGHTING PLAN &
REFLECTED CEILING
PLAN

DATE	DRAWN BY	ISSUED FOR
02/21/03	JAR	PRELIMINARY
03/03/03	JAR	REVISION
03/05/03	JAR	ISSUED FOR BUILDING PERMIT
07/15/03	JAR	SHOW SOFTT HEIGHTS

SEAL

SHEET NO.
E-2.0

PROJECT NO.
02-0436