

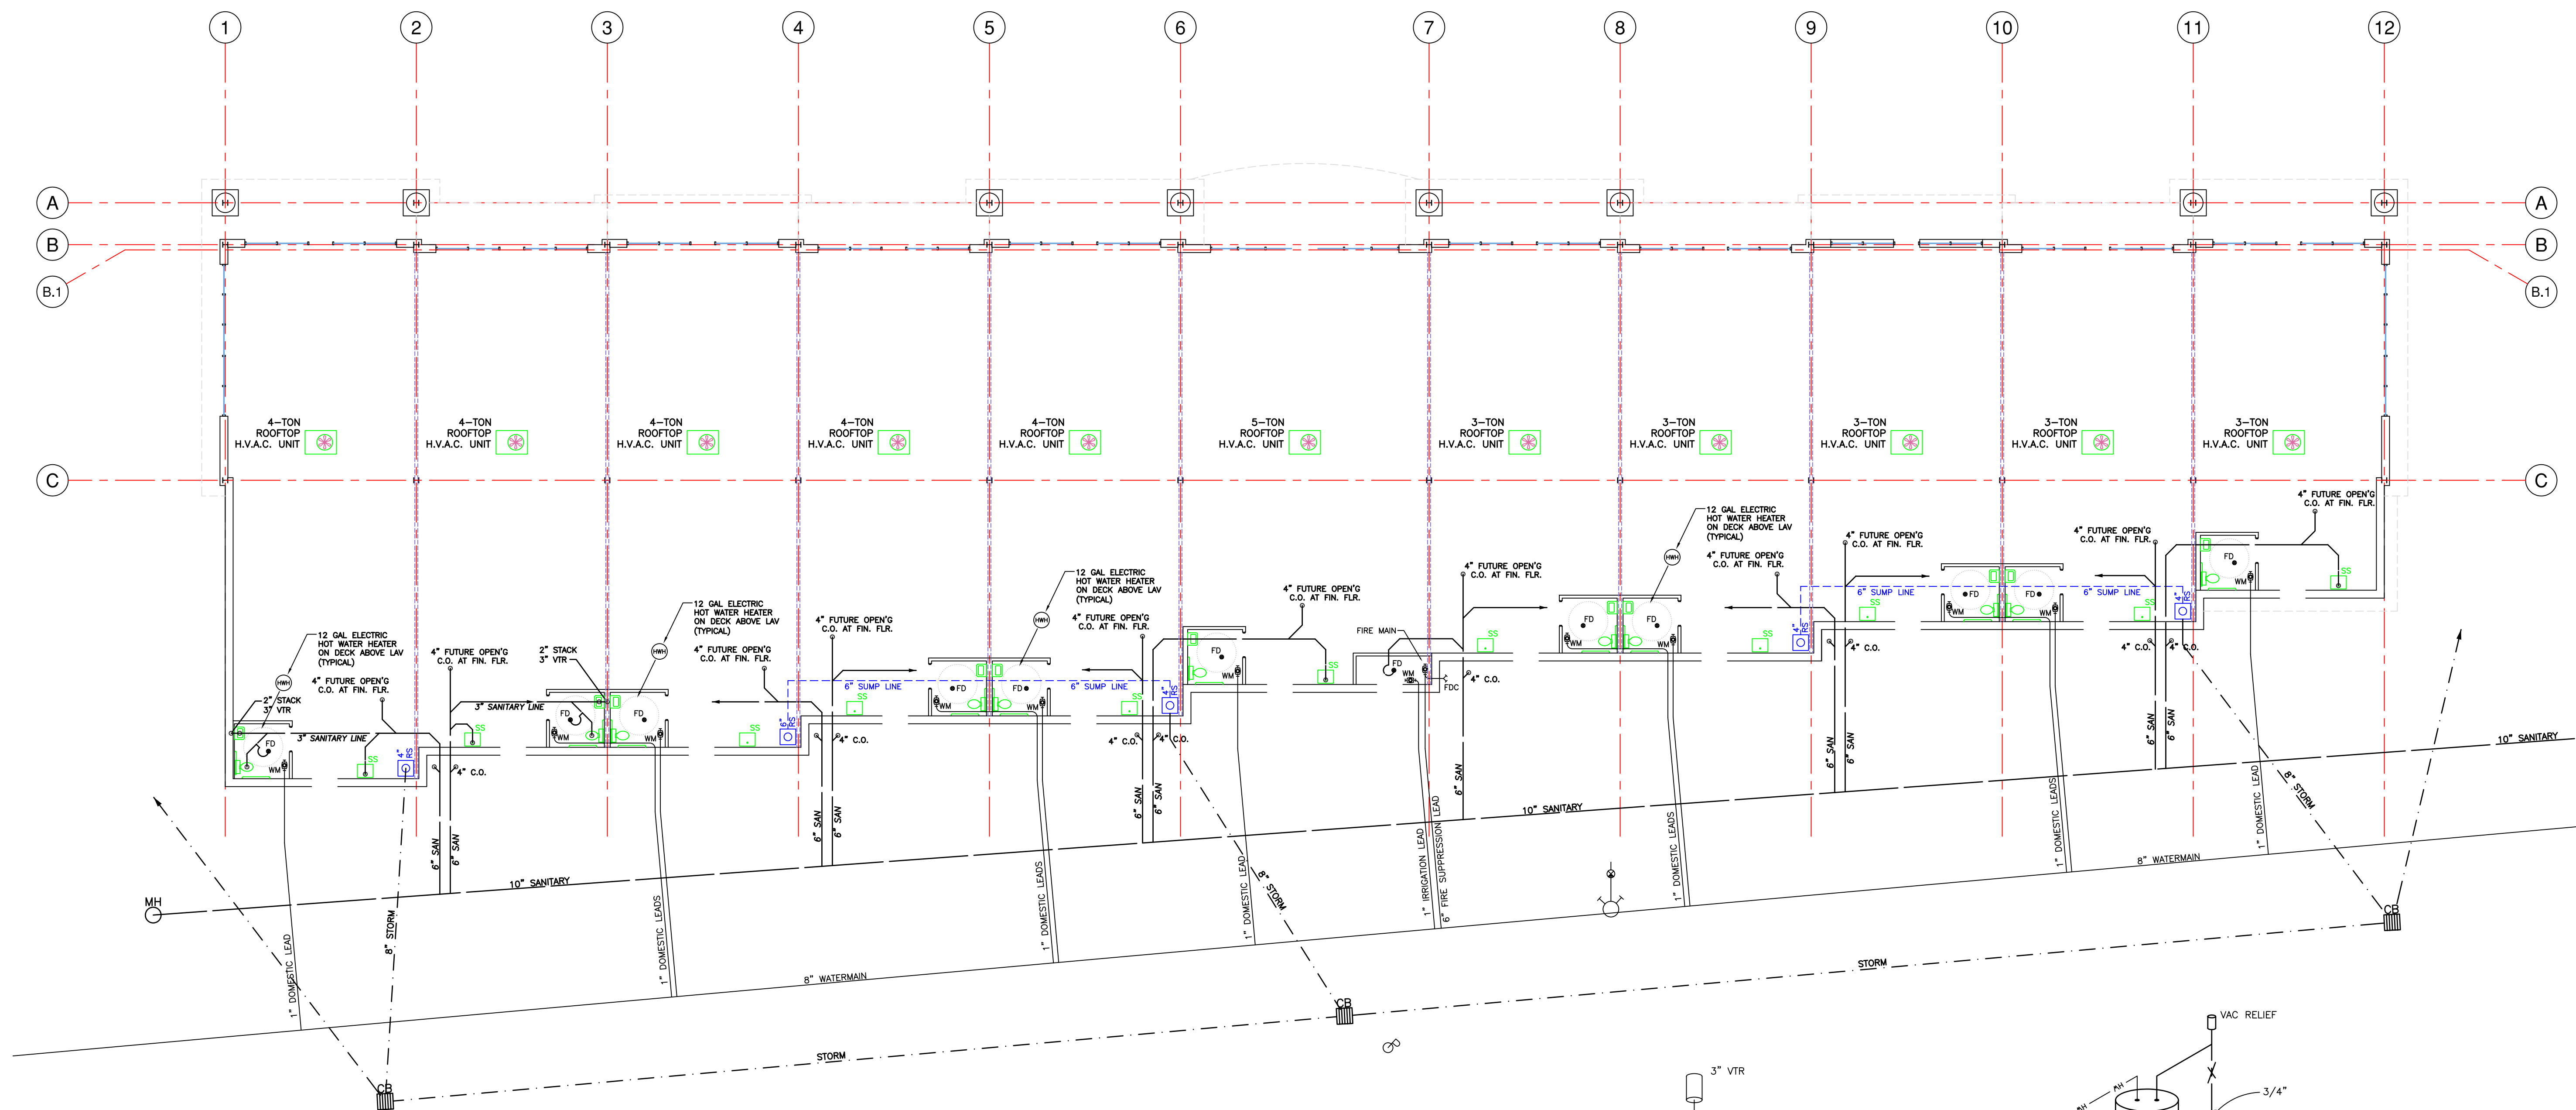


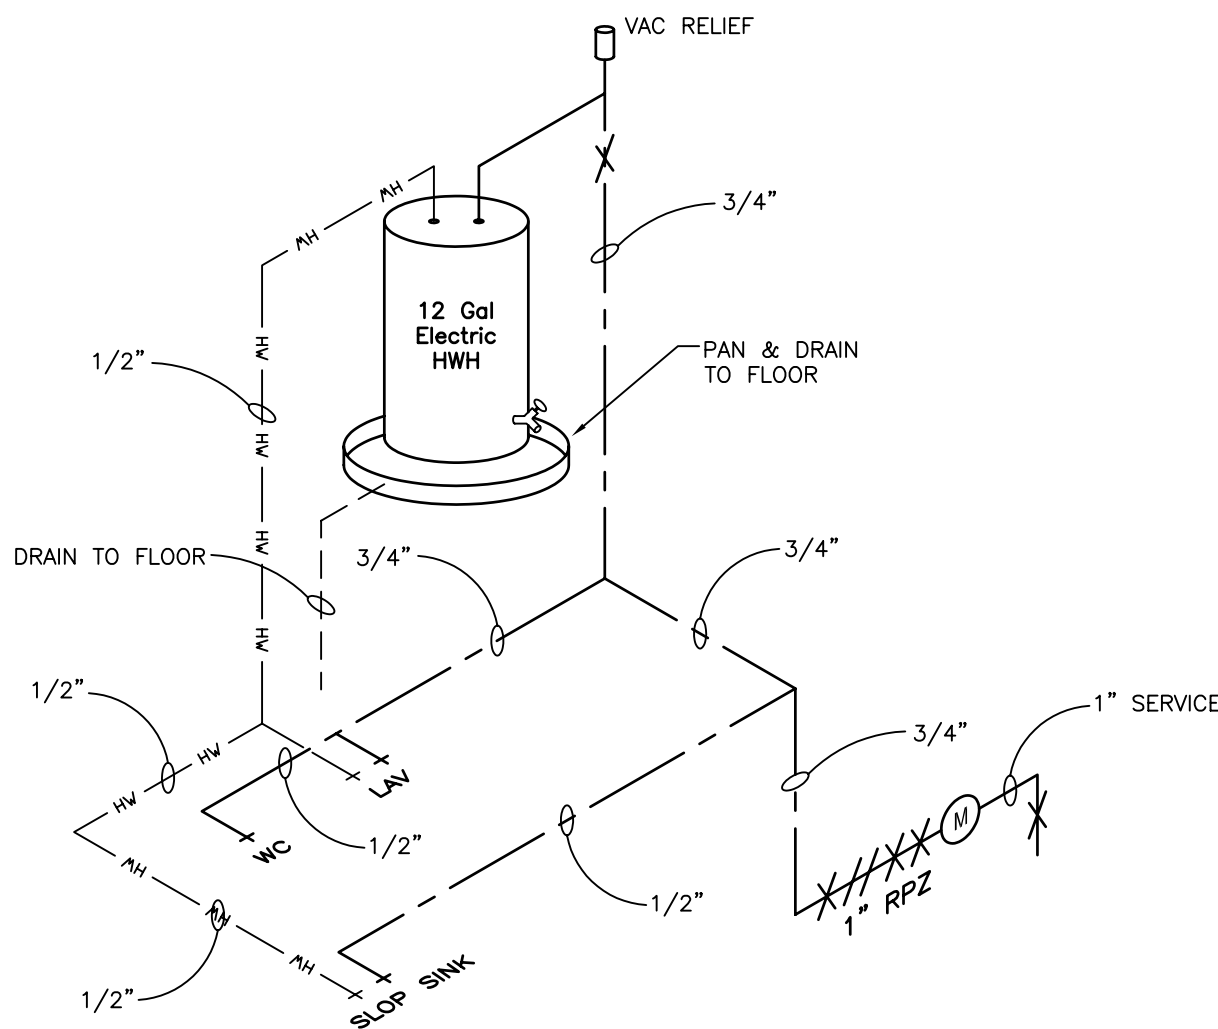

PLUMBING PLAN

SCALE: 3/32" = 1'-0"

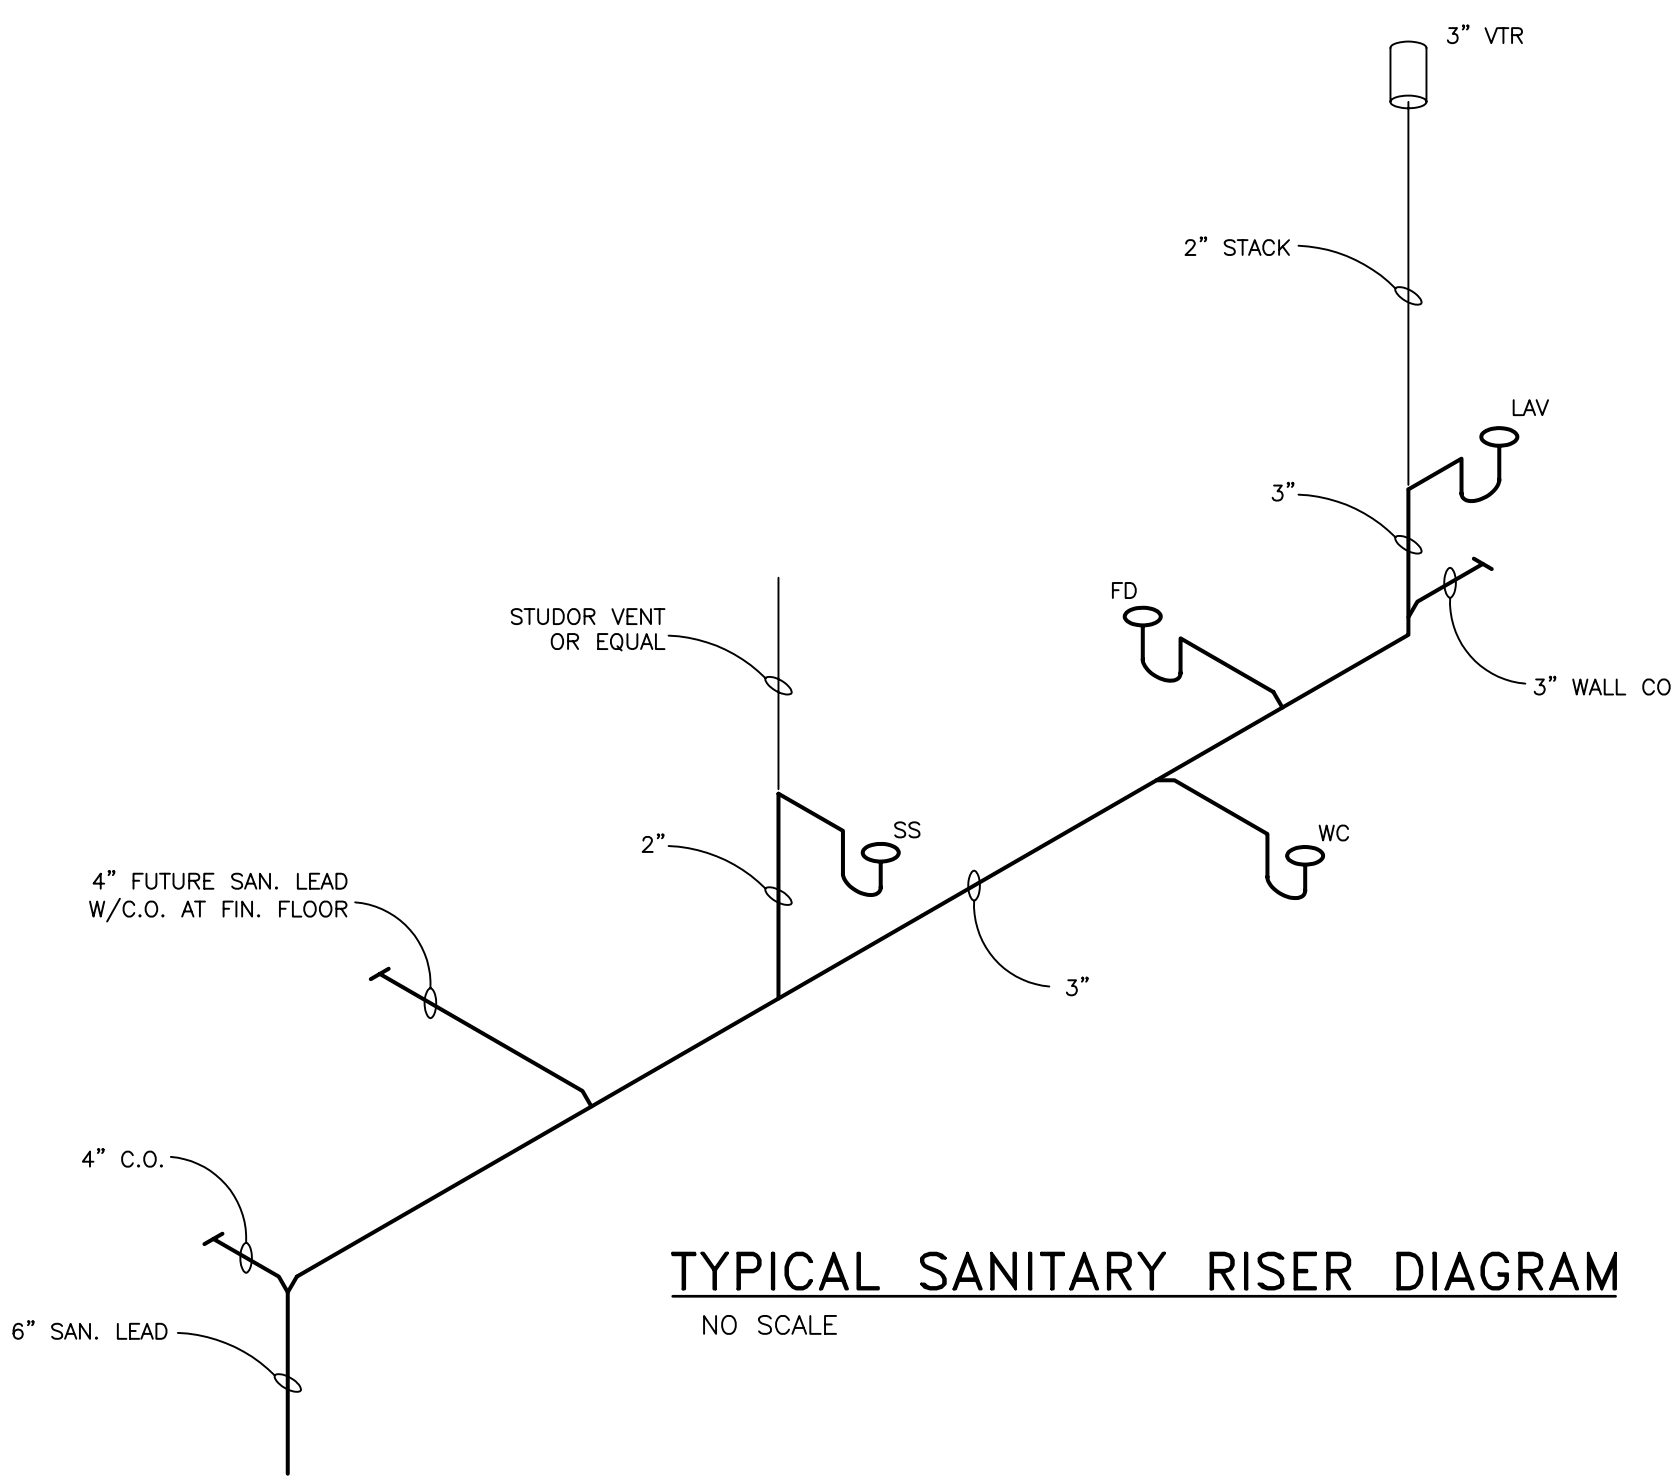

PLEASE NOTE:

THIS DRAWING IS DIAGRAMMATIC AND SHOULD BE USED TO DETERMINE THE DESIGN INTENT. THE CONTRACTOR SHALL FIELD VERIFY ALL WORK AND SHALL NOTIFY THE DESIGNER IMMEDIATELY OF ANY DISCREPANCIES IN THE DOCUMENTS BEFORE PROCEEDING. FAILURE TO DO SO WILL RESULT IN THE CONTRACTOR TAKING ALL RESPONSIBILITY AND LIABILITY IN SAID DISCREPANCIES.

A R Decker & Associates
Consulting Engineers
Civil — Structural
906 East Long Lake Road
Troy, Michigan 48068
Telephone (248) 528-3779
Facsimile (248) 528-3548

CLIENT
RICHARD E. BURGETT
ODESSA BUILDERS, INC.
45000 River Ridge Dr., Suite 200
Clinton Township, MI 48038
Phone: (586) 416-4500
Fax: (586) 226-5666

PROJECT TITLE
ENTERPRISE SQUARE
(Enterprise Square @ Hall)

SHEET TITLE
PLUMBING PLAN
& RISER DIAGRAMS

DATE	DRAWN BY	ISSUED FOR
01/24/03	JAR	PRELIMINARY
02/18/03	JAR	REVISION
03/05/03	JAR	ISSUED FOR BUILDING PERMIT

SEAL

SHEET NO.
P-1.0

PROJECT NO.
02-0436