



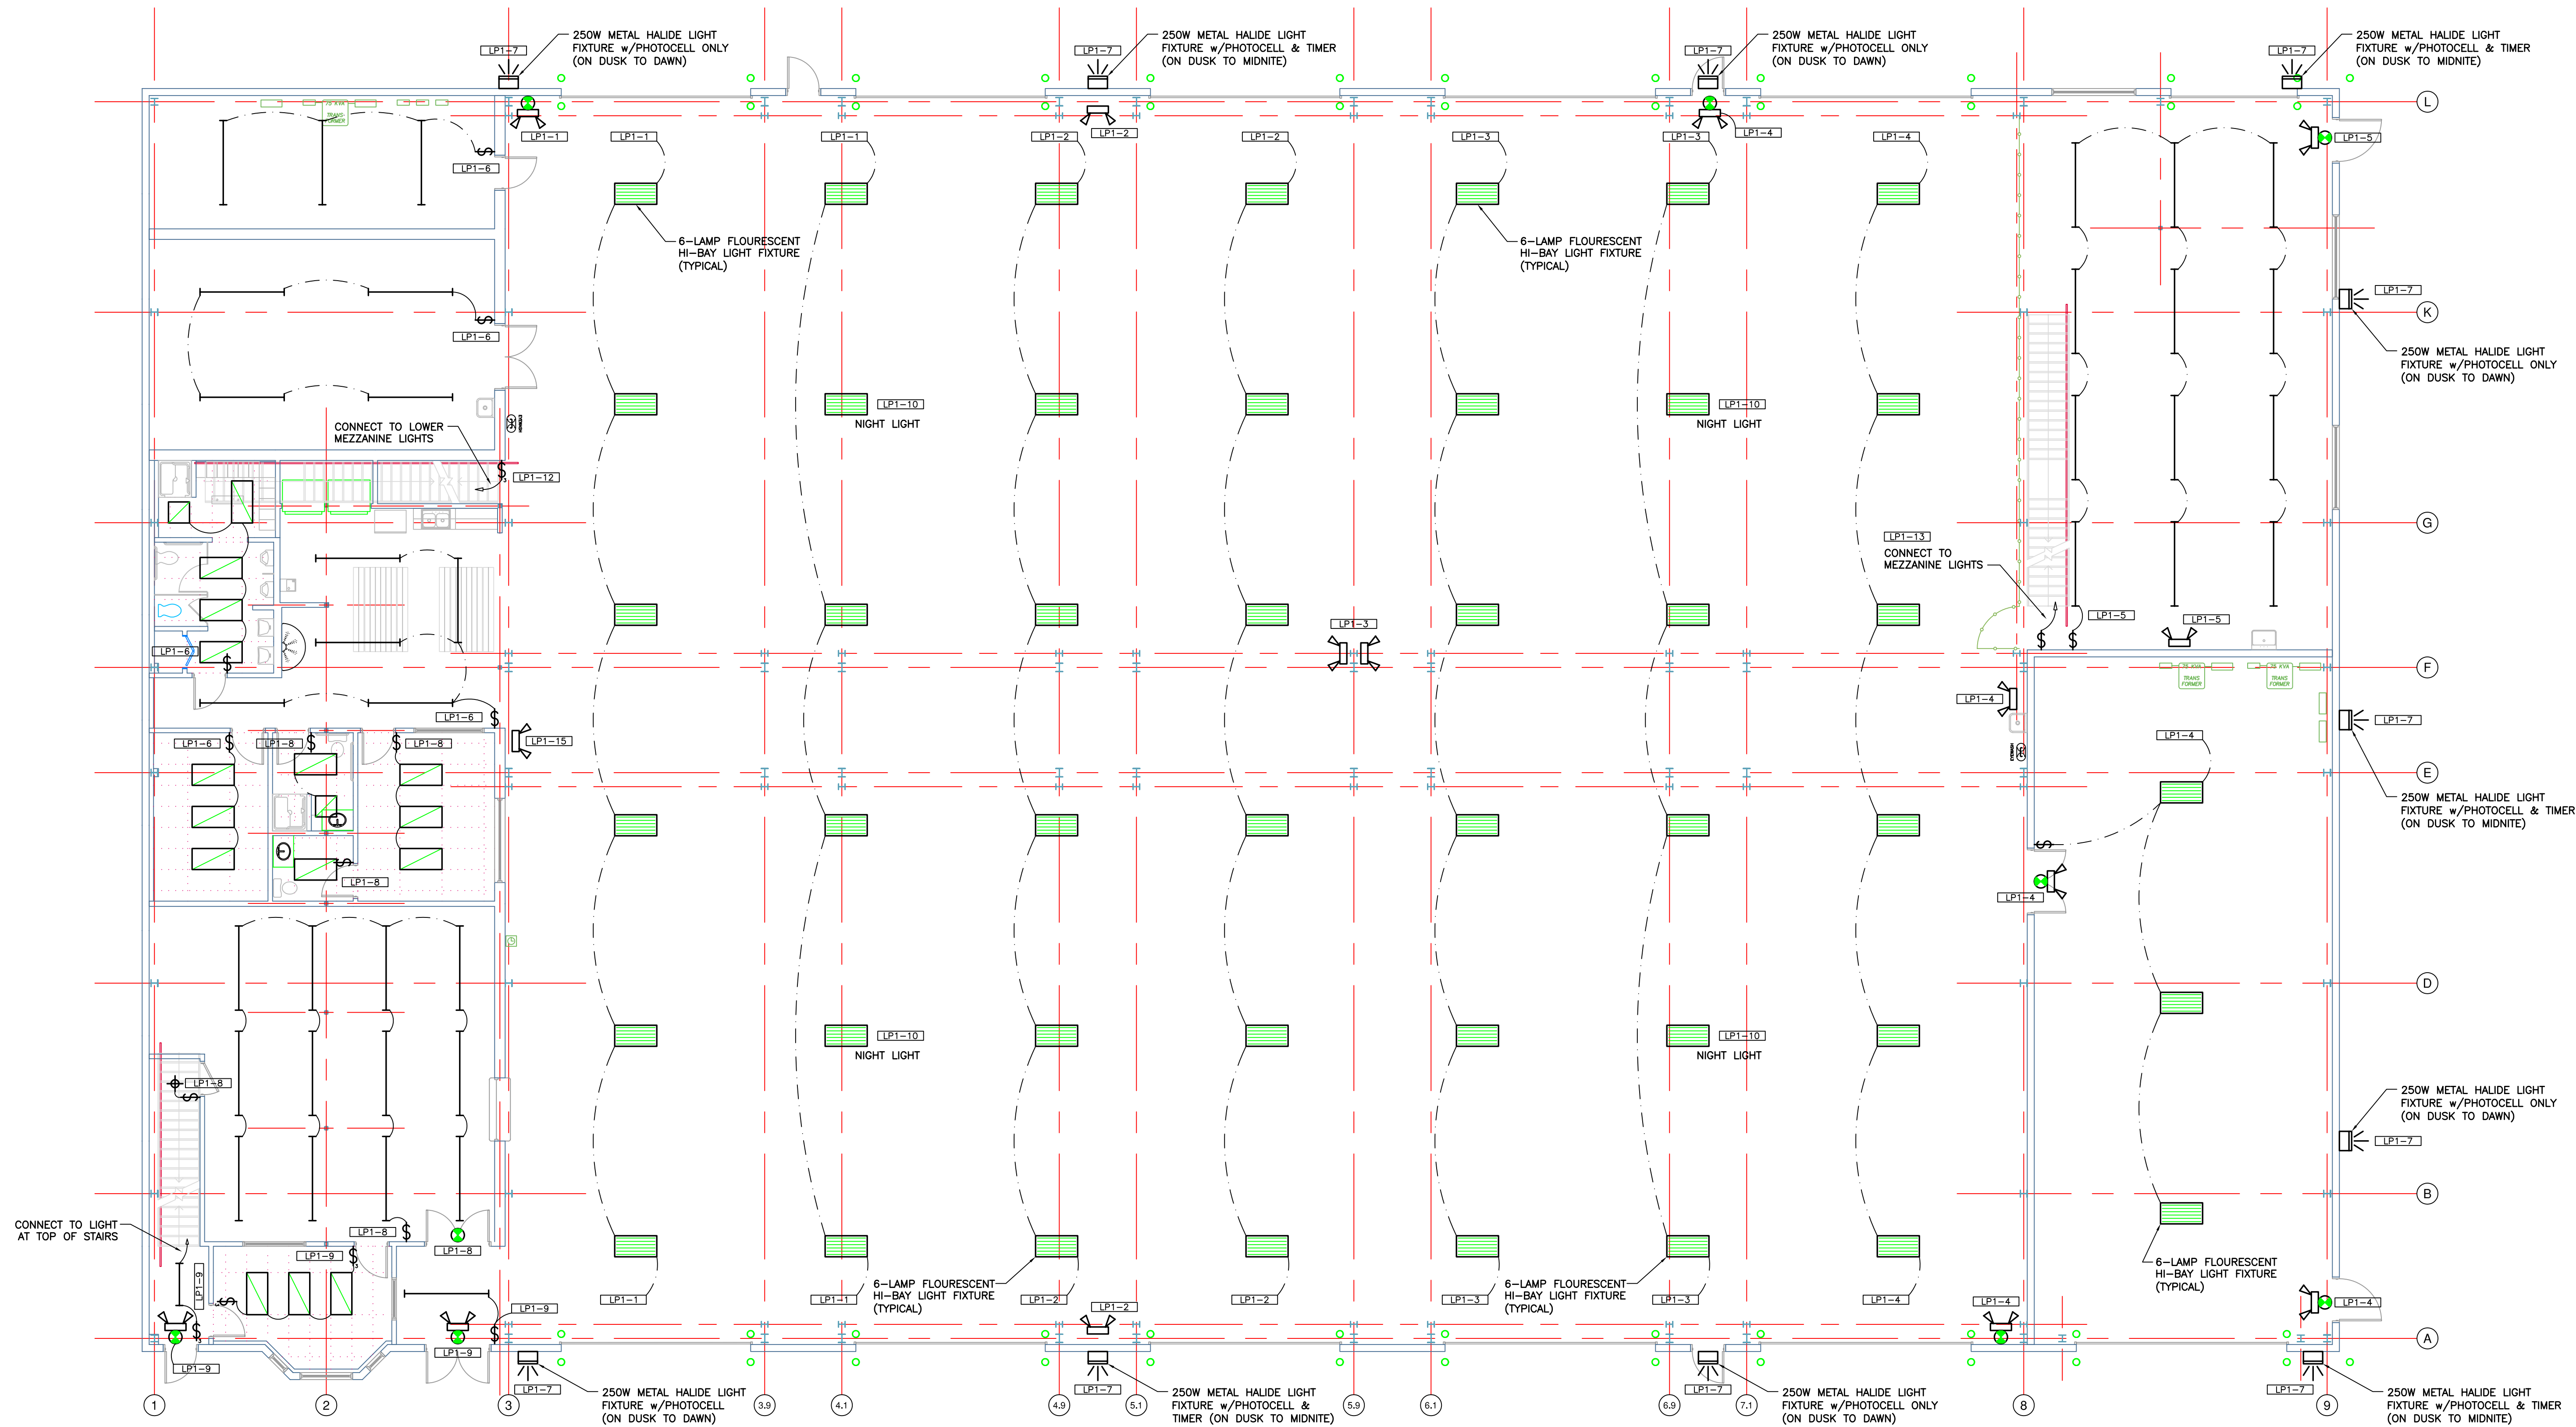

LIGHTING PLAN - MAIN FLOOR

SCALE: 1/8" = 1'-0"

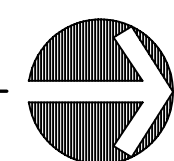

NOTE:
CEILING GRID @ 8'-0" A.F.F. (UNO)

DATE
11/11/03

DRAWN BY
HAR

ISSUED FOR BUILDING PERMIT

SEAL

SHEET NO.
E-2.0

PROJECT NO.
03-0018

SHEET TITLE

LIGHTING PLAN
-MAIN FLOOR
-PHASE ONE

PROJECT TITLE

MAINTENANCE BUILDING

CLIENT

JOHN CARLO, INC.

45000 RIVER RIDGE DR.
SUITE 200, RIVER RIDGE CORP. CENTRE
CLINTON TWP., MI 48038
(586) 416-4500
(586) 226-5666

A R Decker & Associates

Consulting Engineers
Civil - Structural

920 East Long Lake Road
Troy, Michigan 48065
Telephone (248) 528-3779
Facsimile (248) 528-3548