



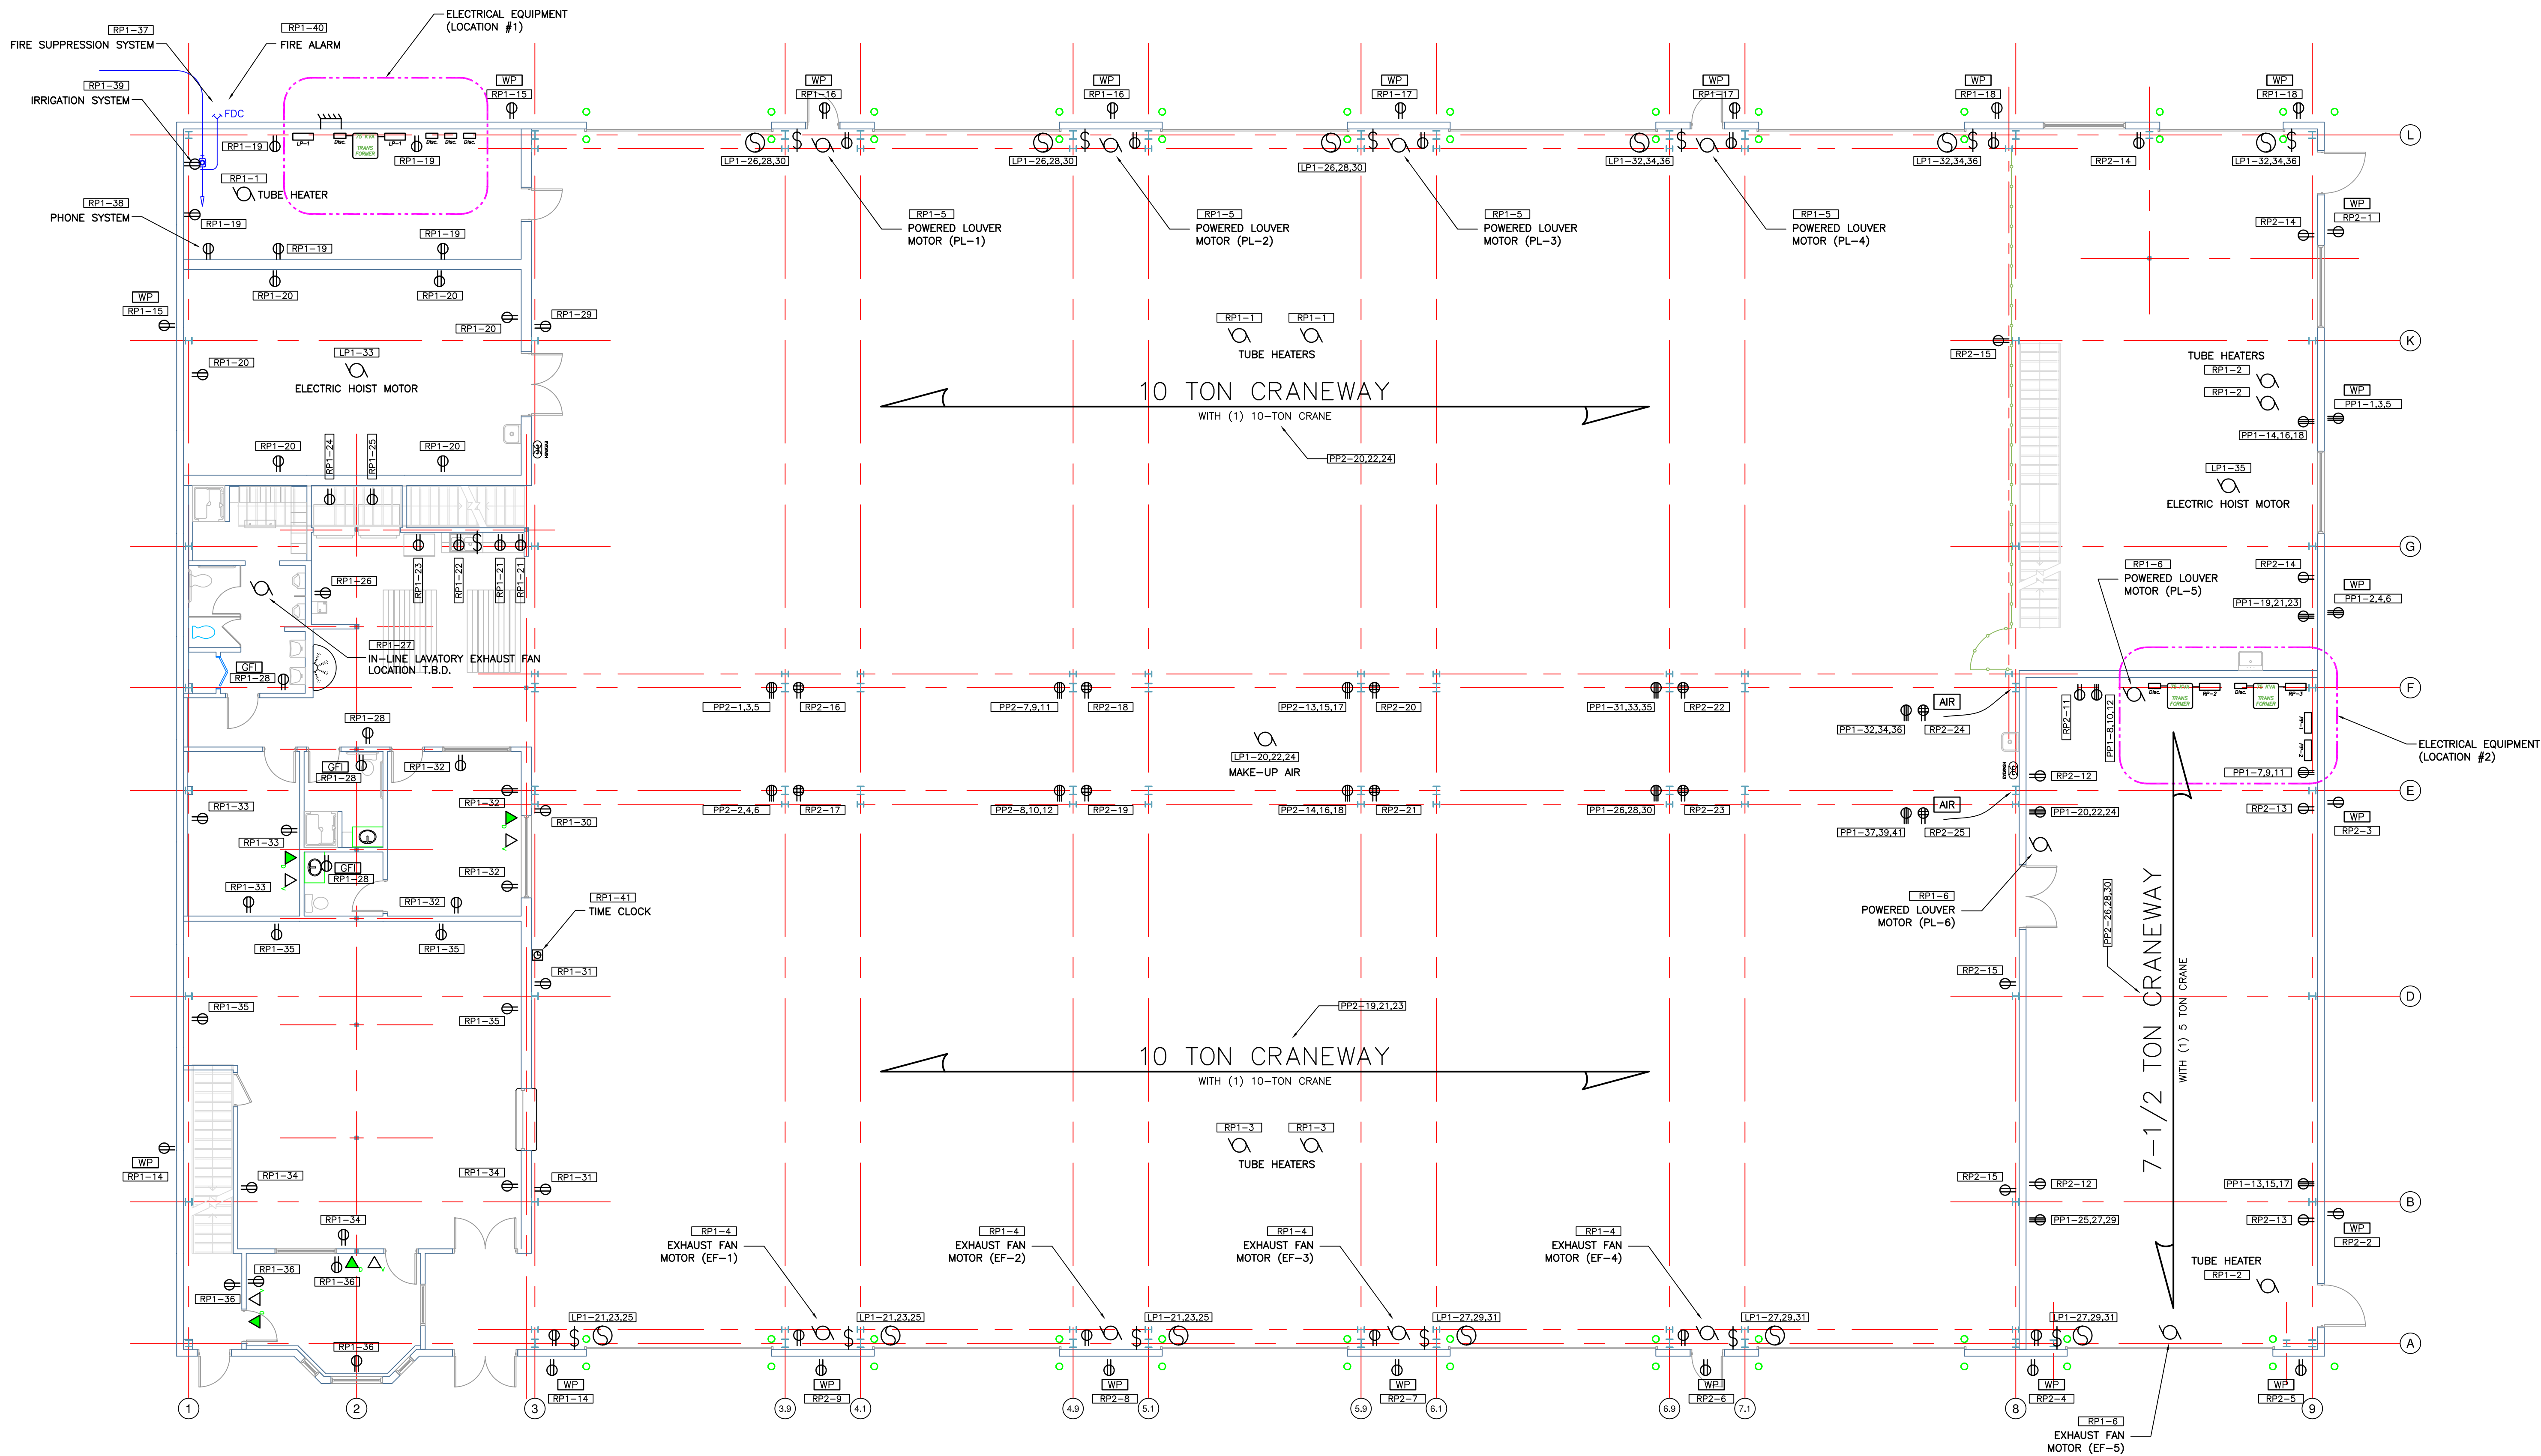

ELECTRICAL PLAN

SCALE: 1/8" = 1'-0"

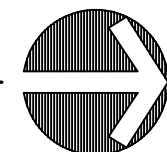

A R Decker & Associates
Consulting Engineers
Civil — Structural
920 East Long Lake Road
Troy, Michigan 48065
Telephone (248) 528-3779
Facsimile (248) 528-3548

CLIENT
JOHN CARLO, INC.

45000 RIVER RIDGE DR.
SUITE 200, RIVER RIDGE CORP. CENTRE
CLINTON TWP., MI 48038
(586) 416-4500
(586) 226-5666

PROJECT TITLE
MAINTENANCE BUILDING

SHEET TITLE
ELECTRICAL PLAN
-MAIN FLOOR
-PHASE ONE

DATE 11/11/03
DRAWN BY JAR
ISSUED FOR BUILDING PERMIT

SEAL

SHEET NO.
E-3.0

PROJECT NO.
03-0018