


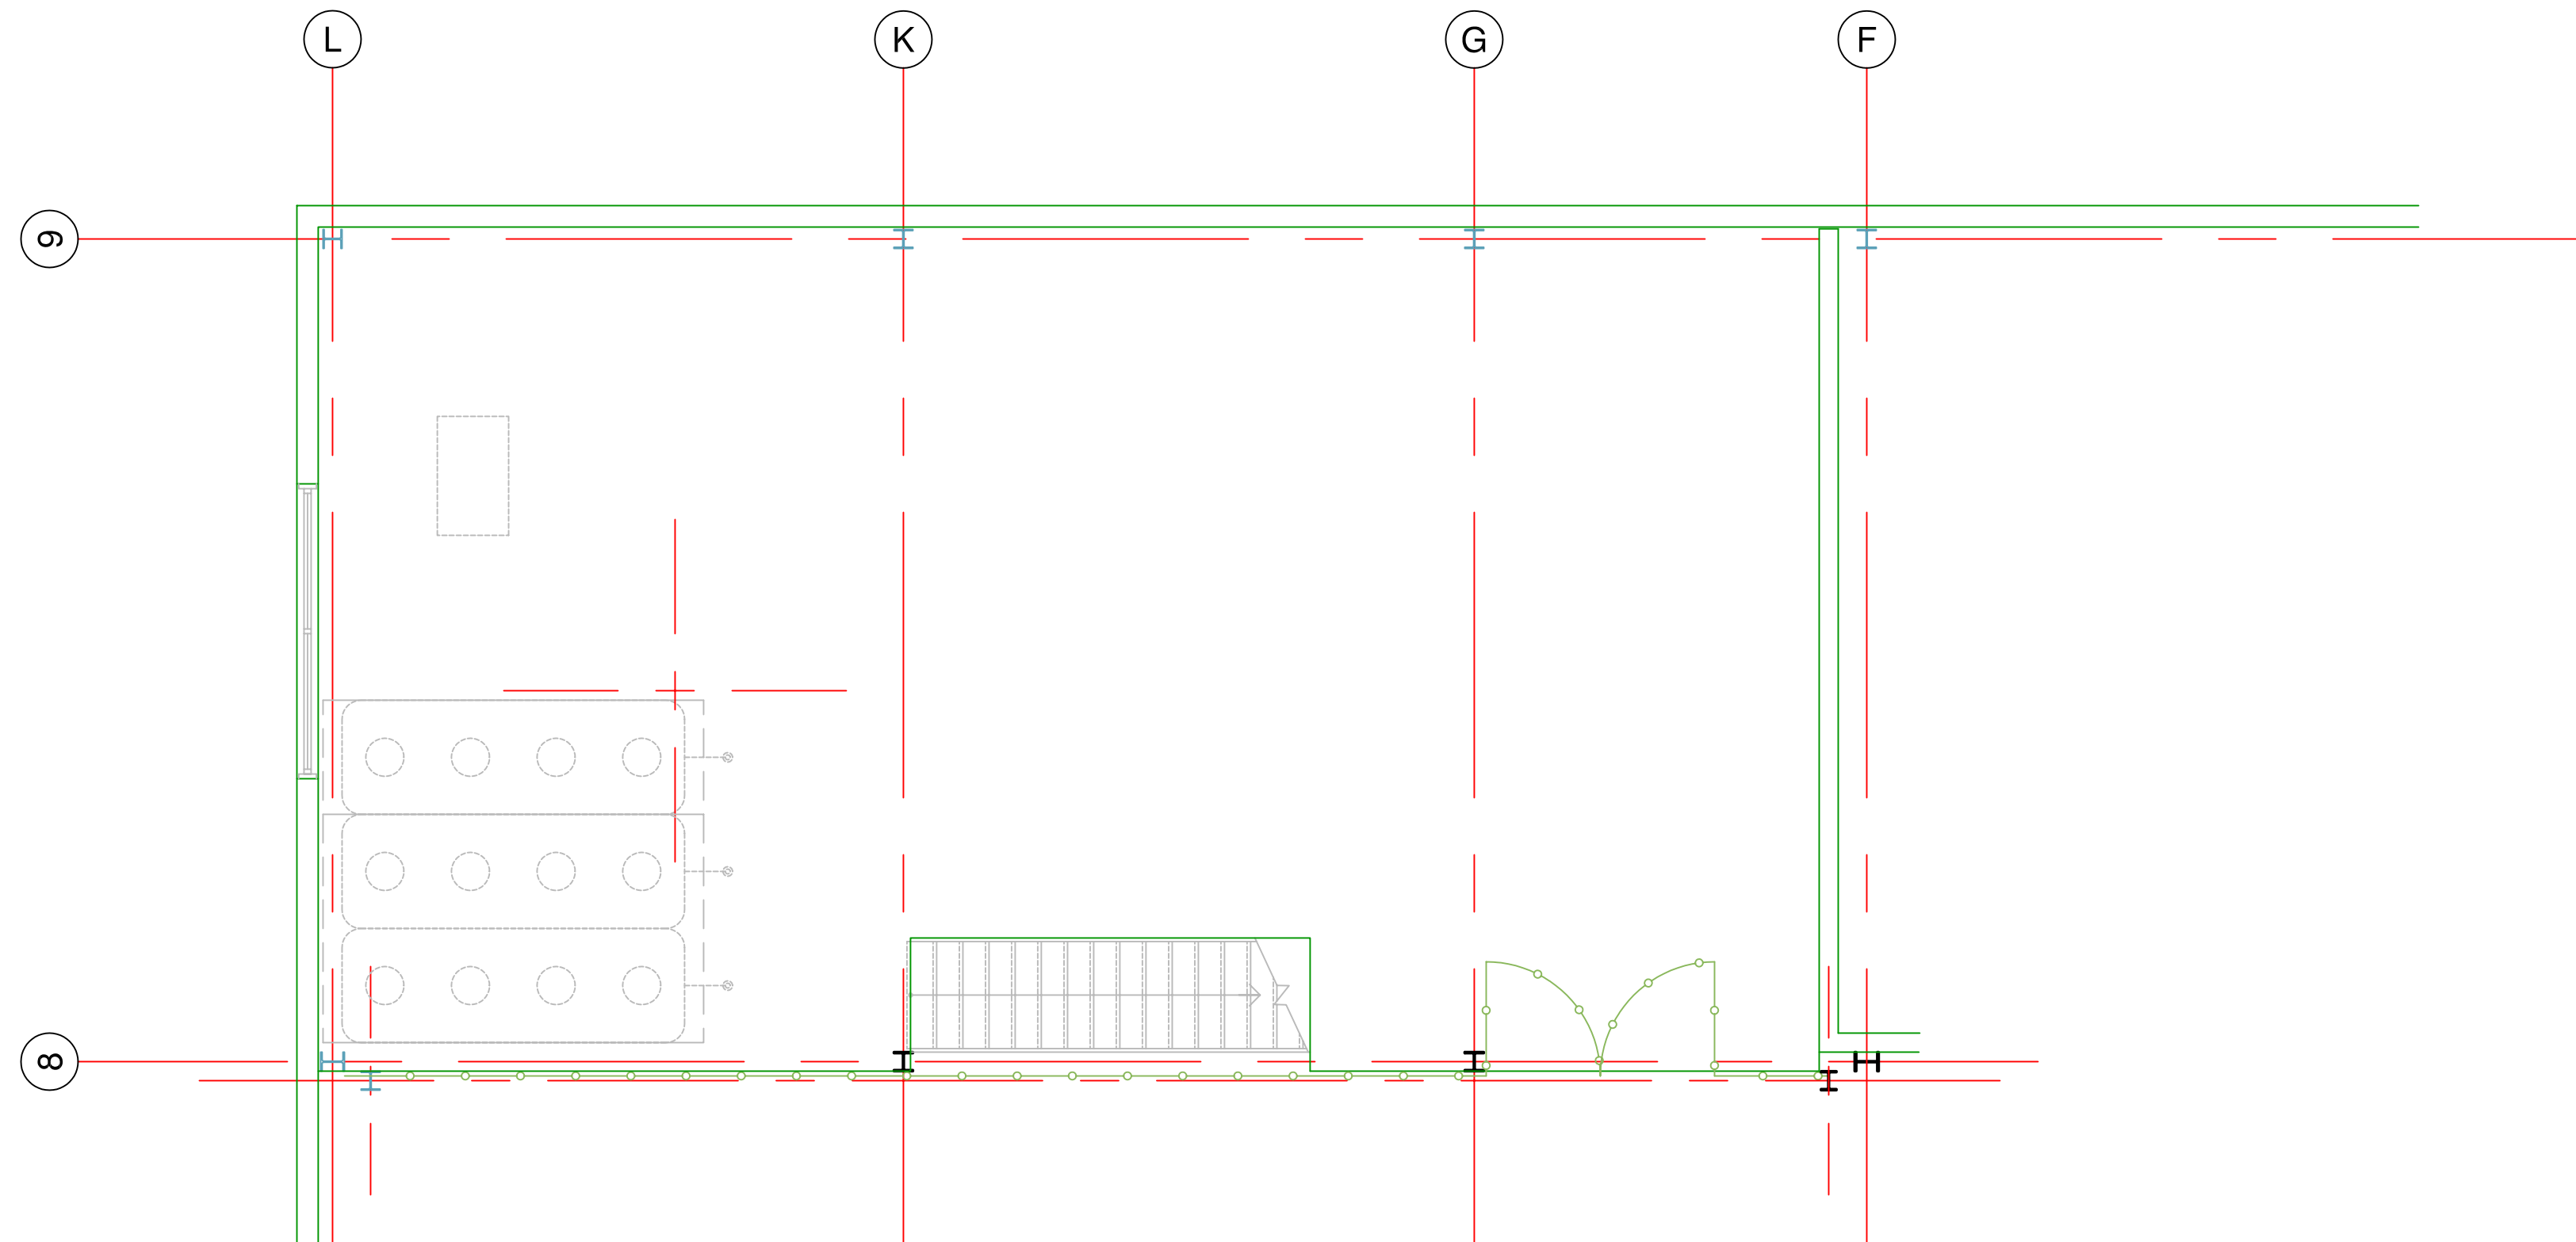


REAR MEZZANINE MECHANICAL PLAN

SCALE: 3/16" = 1'-0"



LEGEND

- | | | | |
|--|---|--|------------------------|
| | RECESSED INCANDESCENT LIGHT FIXTURE | | CIRCUIT TAG |
| | 2'X4' FLUORESCENT LIGHT | | RETURN AIR GRILLE |
| | 2'X4' FLUORESCENT LIGHT W/PARABOLIC LENS | | SUPPLY AIR DIFFUSER |
| | 2'X4' FLUORESCENT NIGHT LIGHT | | LAVATORY EXHAUST FAN |
| | 2'X2' FLUORESCENT LIGHT | | FAN MOTOR |
| | 2'X2' FLUORESCENT LIGHT W/PARABOLIC LENS | | O.H. DOOR MOTOR |
| | 8'-0" TWIN-TUBE FLUORESCENT LIGHT FIXTURE | | 110V DUPLEX RECEPTACLE |
| | 4'-0" TWIN-TUBE FLUORESCENT LIGHT FIXTURE | | 110V QUAD RECEPTACLE |
| | 6 LAMP HI-BAY FLORESCENT LIGHT FIXTURE | | 220V RECEPTACLE |
| | 400W METAL HALIDE LIGHT FIXTURE | | LIGHT SWITCH |
| | 400W METAL HALIDE RE-STRIKE LIGHT FIXTURE | | 3-WAY LIGHT SWITCH |
| | EXTERIOR WALL-MOUNTED LIGHT FIXTURE | | LIGHT DIMMER SWITCH |
| | EXIT SIGN | | VOICE JACK |
| | EMERGENCY LIGHT | | DATA JACK |
| | EXTERIOR MEANS OF EGRESS LIGHT FIXTURE | | SPRINKLER HEAD |

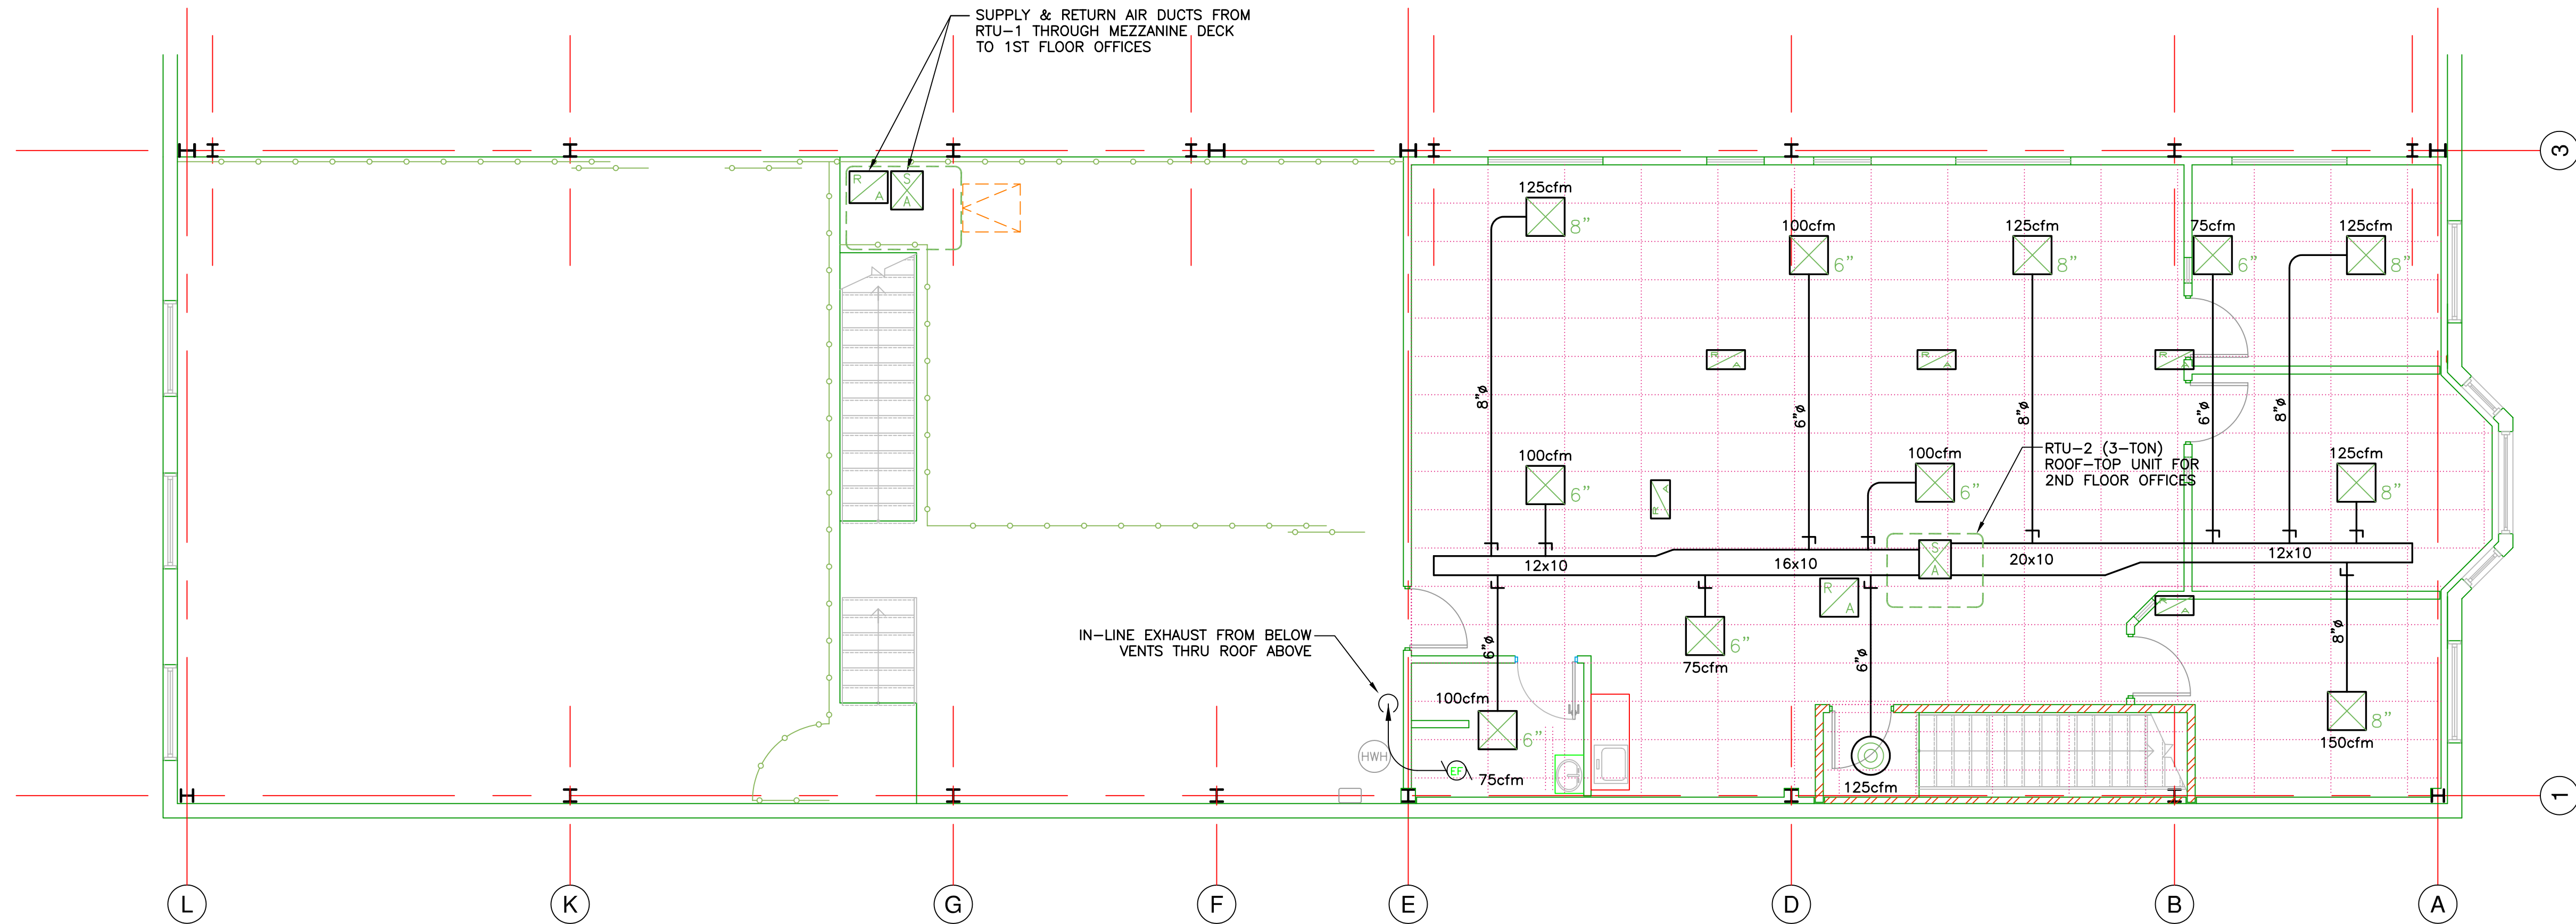

FRONT MEZZANINE MECHANICAL PLAN

SCALE: 3/16" = 1'-0"



NOTE!
CEILING GRID @ 8'-0" A.F.F. (UNO)

A R Decker & Associates
Consulting Engineers
Civil — Structural
906 East Long Lake Road
Troy, Michigan 48098
Telephone (248) 528-3779
Facsimile (248) 528-3548

CLIENT
JOHN CARLO, INC.

45000 RIVER RIDGE DR.
SUITE 200, RIVER RIDGE CORP. CENTRE
CLINTON TWP., MI 48038
(586) 416-4500
(586) 226-5666

PROJECT TITLE
MAINTENANCE BUILDING

14889 33 MILE ROAD
BRUCE TWP., MI 48065

SHEET TITLE
FRONT &
REAR MEZZANINE
MECHANICAL PLANS

DATE	DRAWN BY	ISSUED FOR
11/07/03	JAR	ISSUED FOR BUILDING PERMIT
03/26/04	JAR	SHOW CEILING GRID
10/26/04	JAR	CHANGE OFFICE LAYOUT

SEAL

SHEET NO.
M-1.1

PROJECT NO.
03-0018