



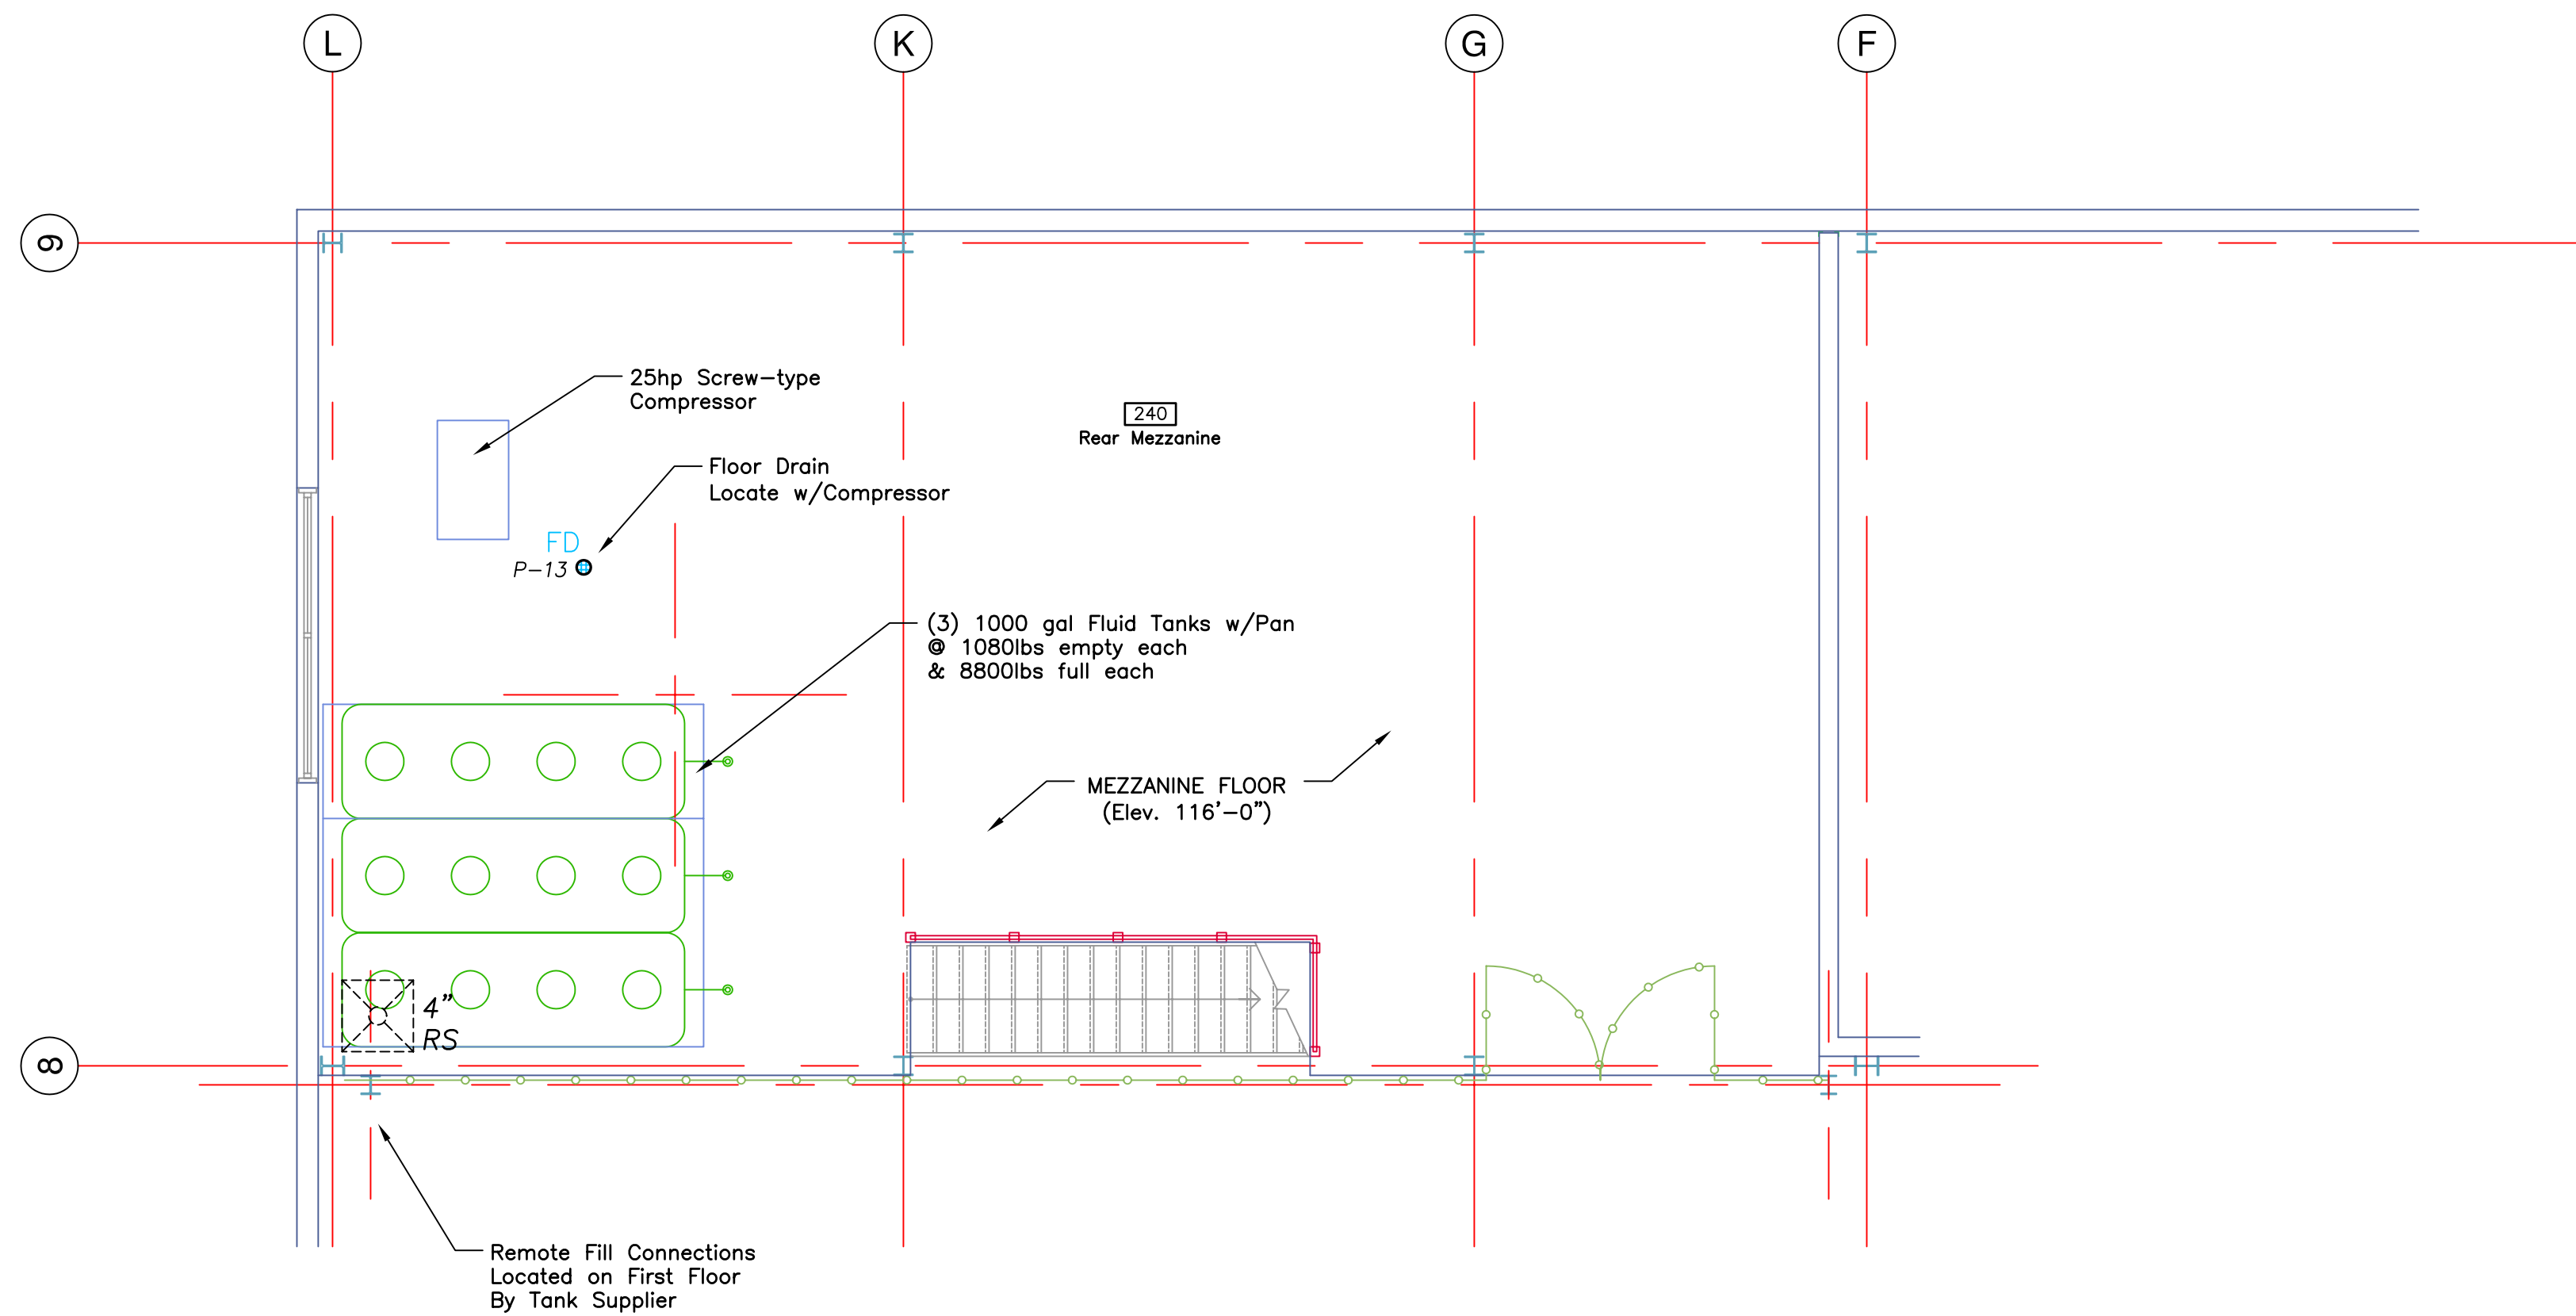

REAR MEZZANINE PLAN

SCALE: 3/16" = 1'-0"

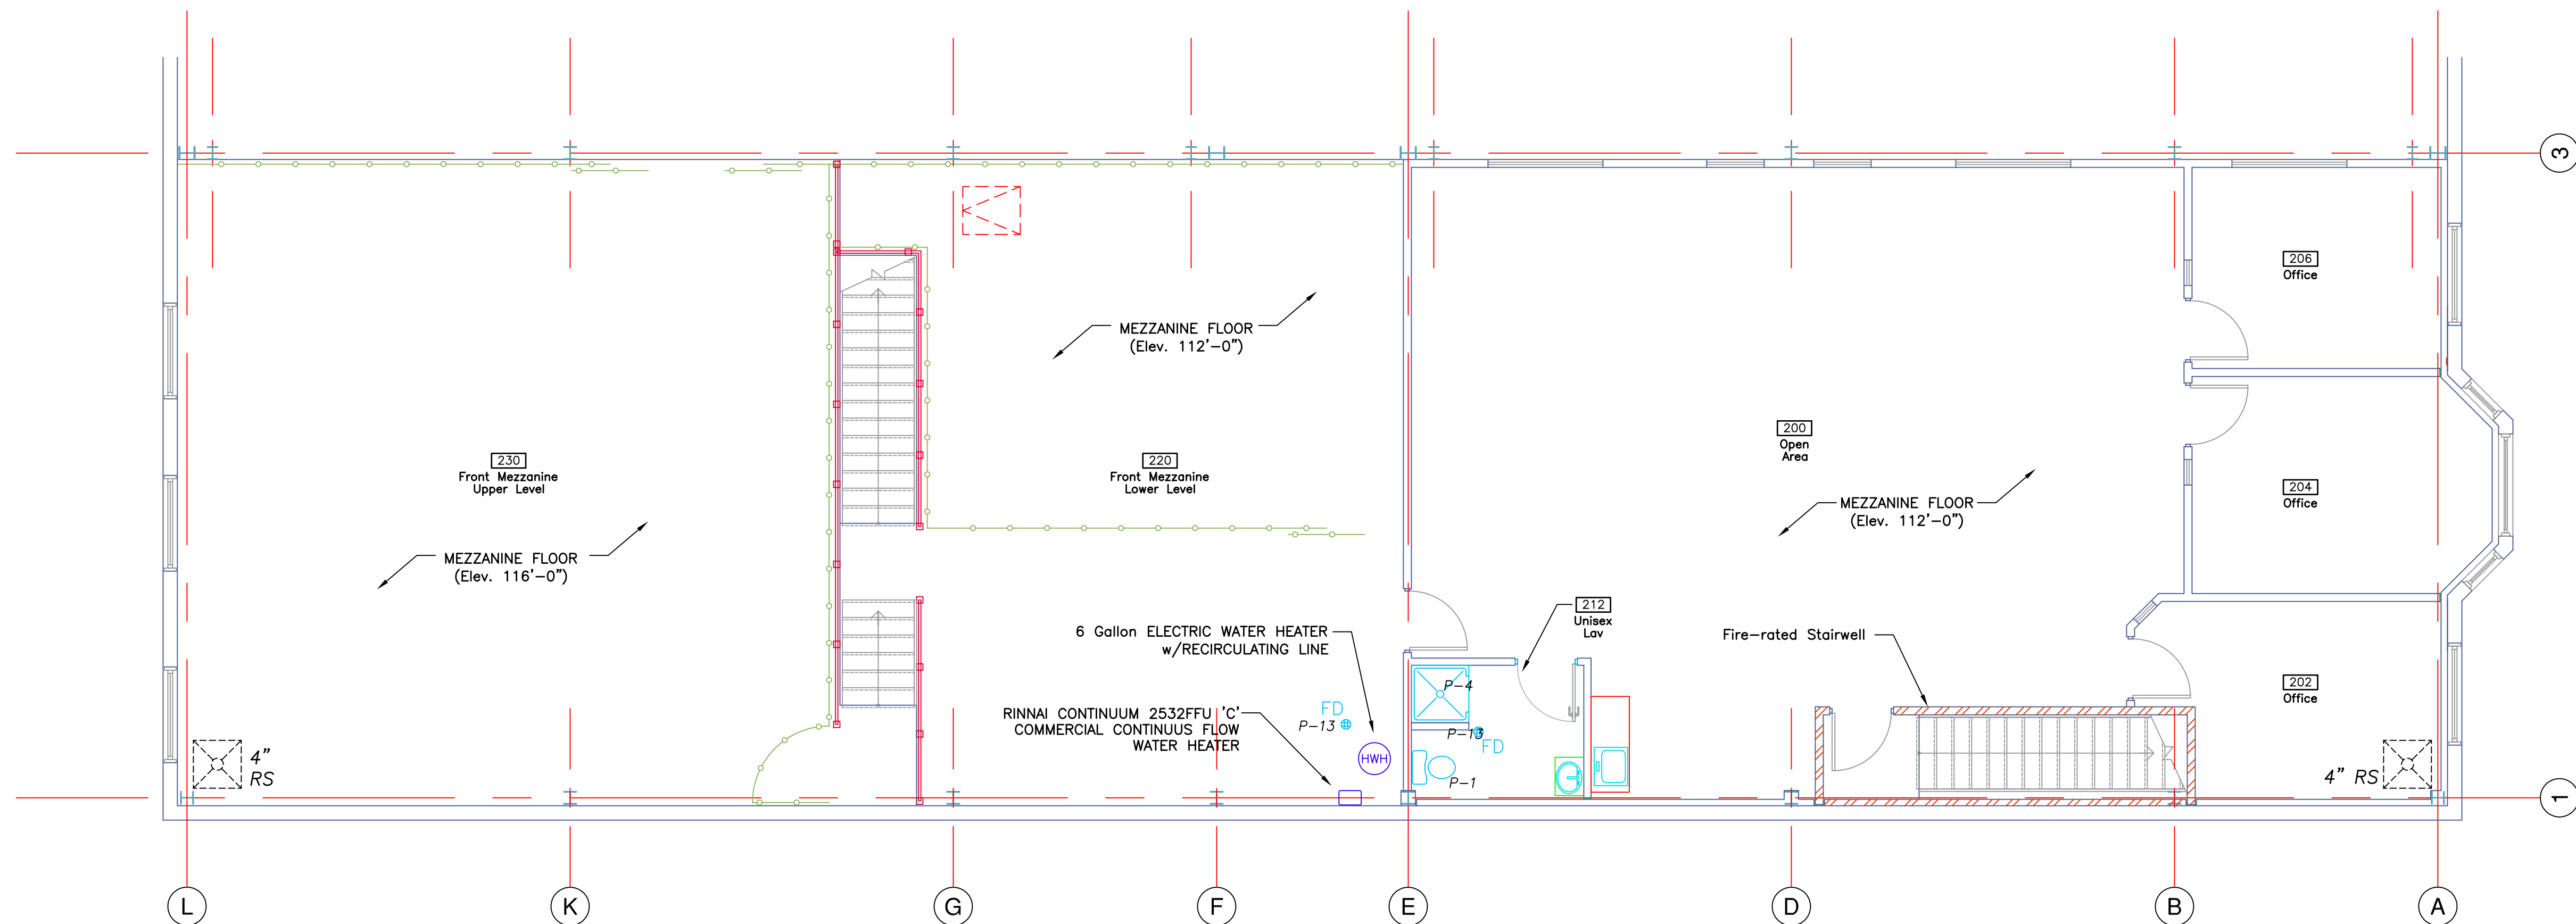

FRONT MEZZANINE PLAN

SCALE: 3/16" = 1'-0"

PLUMBING FIXTURES:			
P-1	Tank Type Water Closet		
	Kohler K-3427 or similar	White	
	K-4650A Seat or similar	White	
P-2	Sloan Valve-type Water Closet		
	Kohler K-4302 or similar	White	
	K-4670C Seat or similar	White	
	Sloan Royal #111 or equal	CP	
P-3	Wall-hung Urinal		
	Kohler K-5016-ET or similar	White	
	Sloan Royal #186 or equal	CP	
P-4	Countertop Lavatory		
	Kohler K-2196 or similar	White	
	Delta 2500 Faucet or equal	Chrome	
	K-7715 Grid Drain or equal	CP	
P-5	Wall-hung Lavatory		
	Kohler K-2030 or similar	White	
	K-7443-2A Faucet or equal	CP	
	K-7715 Grid Drain or equal	CP	
	Zurn Z1231 Concealed Arm Carrier		
P-6	Kitchen Sink		
	Kohler K-3346-3 or similar	Stainless	
	K-8813 Sink Stainer or equal	CP	
	Delta 300-WF Faucet or equal	Chrome	
	In-Sink-Erator Pro333 Disposal		
P-7	Service Sink		
	Kohler K-6650 or similar	White	
	K-8905 Faucet	RP	
	K-6672 2" Trap	N/A	
P-8	Utility Sink		
	Kohler K-12794 or similar	White	
	K-7313-K Faucet or equal	CP	
	K-16012-5 Lever Handles or equal	CP	
	K-9115 Strainer or equal	CP	
P-9	Barrier-Free Shower Stall		
	Kohler K-12108-C or similar	White	
	K-701217-B-SH Pivot Shower Door	SH	
	K-T6910-4A Shower Faucet or equal	CP	
	K-304-K Balance Valve or equal	N/A	
	K-9132 Shower Drain	CP	
P-10	Semi-Circular Handwash Sink		
	Bradley Sentry Washfountain		
	#SN2004/A/AST/STD/PBV/LSD/BS	Stainless	
P-11	Electric Water Cooler		
	Elkay #EVS4 Barrier-Free Water Cooler	Gray	
P-12	Emergency Shower & Eye Wash		
	Bradley Model S19-310BF	Yellow	
P-13	Floor Drains - As Required		

CLIENT	A R Decker & Associates			
	Consulting Engineers Civil — Structural			
PROJECT TITLE	JOHN CARLO, INC.			
	45000 RIVER RIDGE DR. SUITE 200, RIVER RIDGE CORP. CENTRE CLINTON TWP., MI 48038 (586) 416-4500 (586) 226-5666			
SHEET TITLE	MAINTENANCE BUILDING			
	14889 33 MILE ROAD BRUCE TWP., MI 48065			
DATE	04/21/04			
	05/18/04			
DRAWN BY	HJR			
	HJR			
ISSUED FOR	ISSUED FOR BIDS			
	ADD REAR MEZZ. FLOOR DRAIN			
FOR	FOR			
	FOR			
CHANGE	CHANGE			
	CHANGE			
LAYOUT	LAYOUT			
	LAYOUT			
SEAL				
SHEET NO.				
P-1.1				
PROJECT NO.				
03-0018				