



4

3

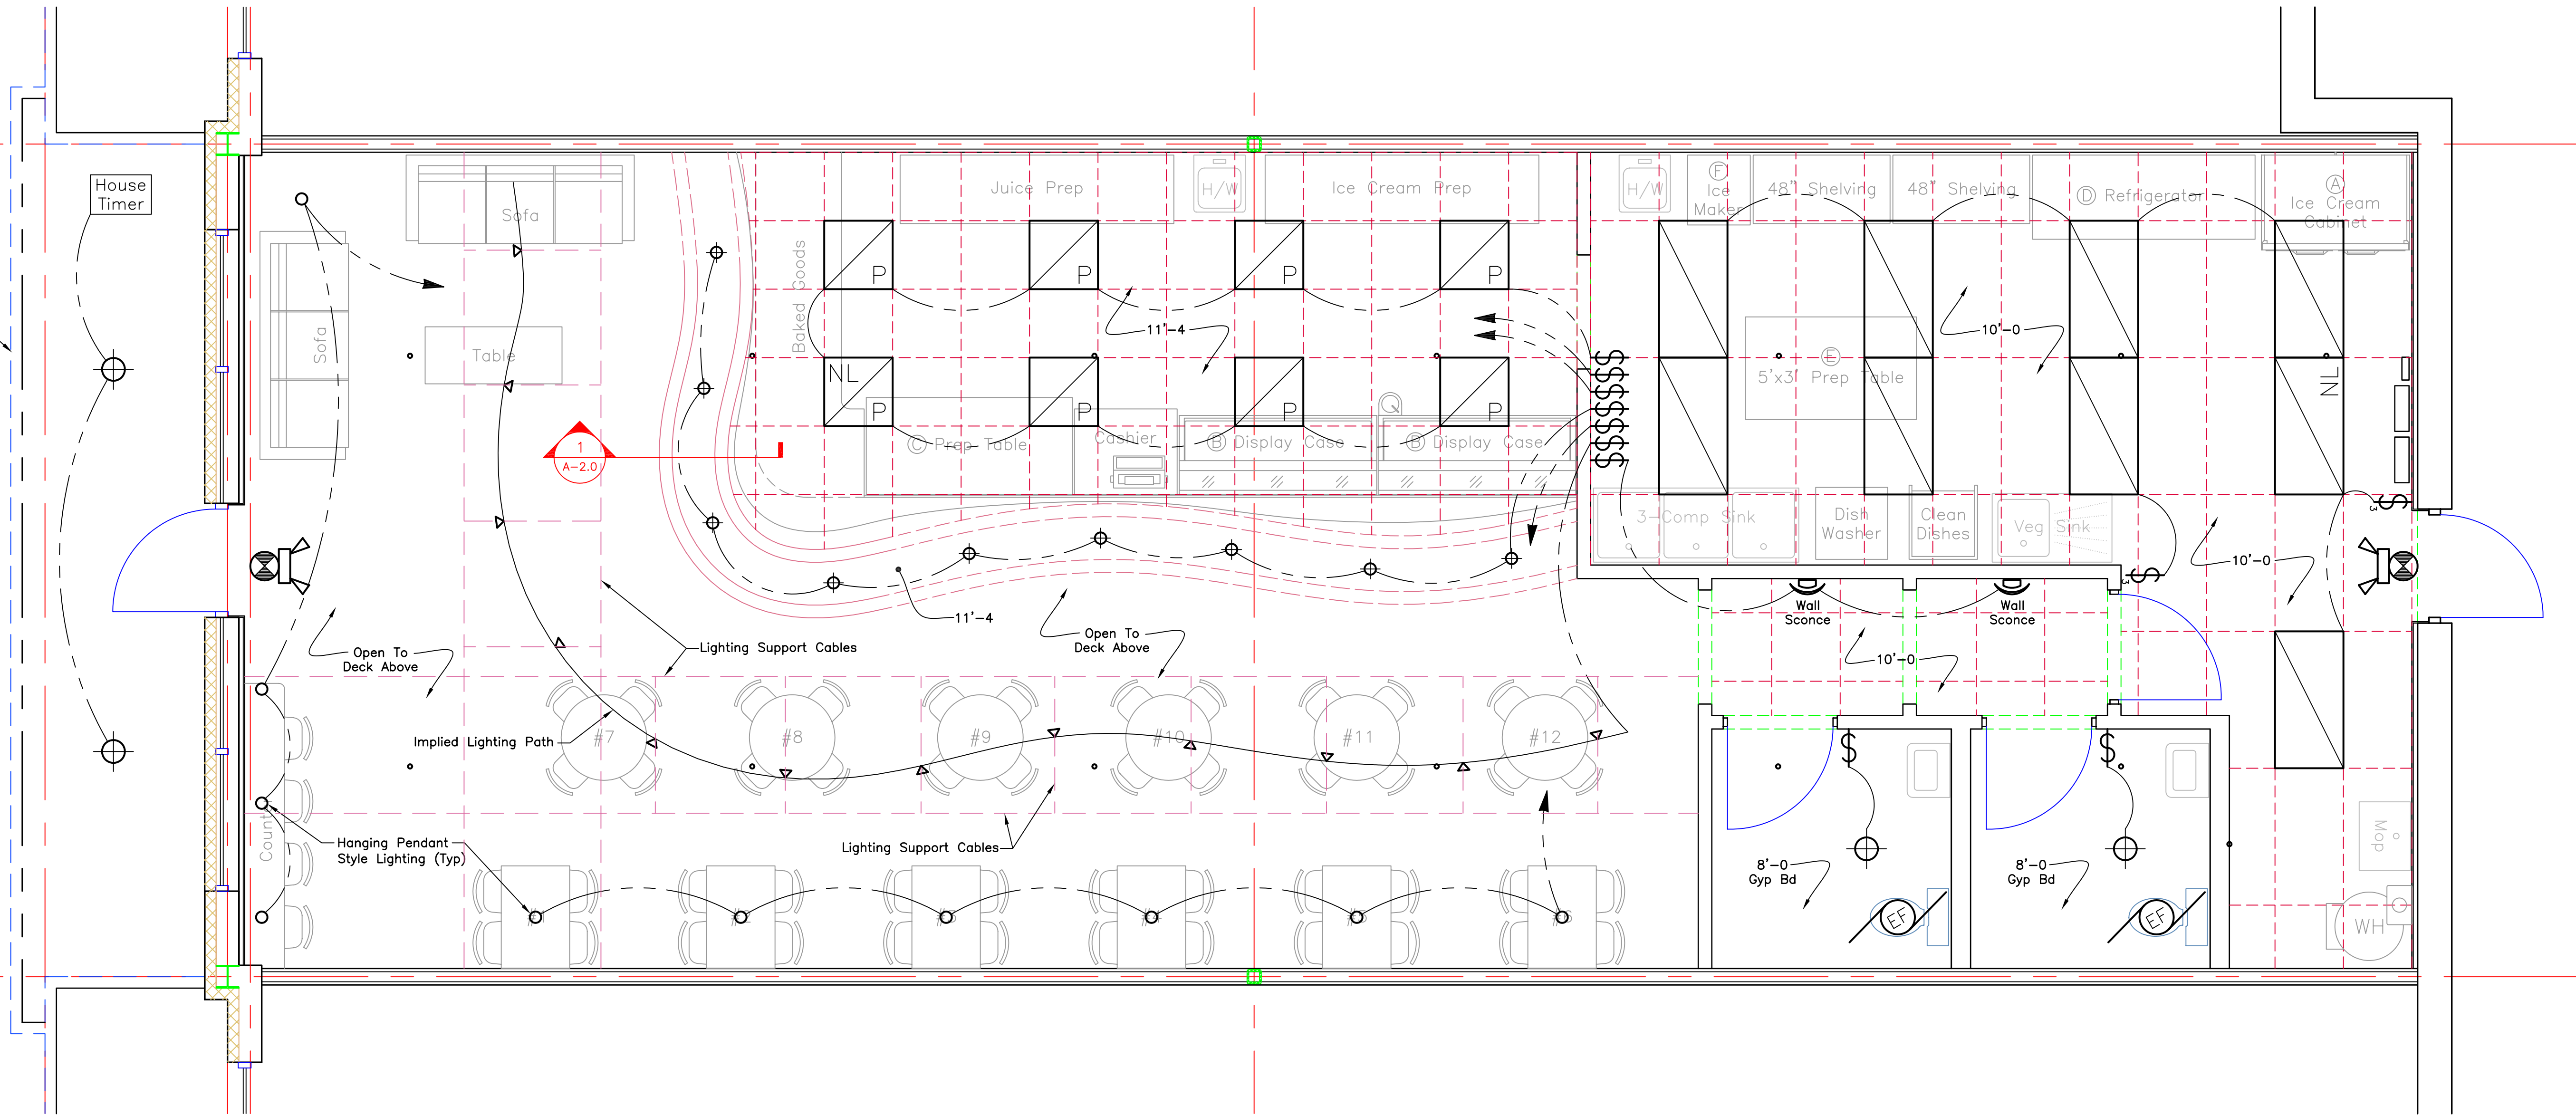

LIGHTING PLAN

SCALE: 3/8" = 1'-0"

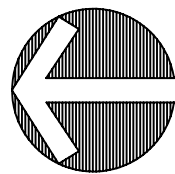

LEGEND

- RECESSED INCANDESCENT LIGHT FIXTURE
- 2'X4' FLUORESCENT LIGHT
- 2'X4' FLUORESCENT LIGHT W/PARABOLIC LENS
- 2'X4' FLUORESCENT NIGHT LIGHT
- 2'X2' FLUORESCENT LIGHT
- 2'X2' FLUORESCENT LIGHT W/PARABOLIC LENS
- 8'-0" TWIN-TUBE FLUORESCENT LIGHT FIXTURE
- 4'-0" TWIN-TUBE FLUORESCENT LIGHT FIXTURE
- 6 LAMP HI-BAY FLORESCENT LIGHT FIXTURE
- 400W METAL HALIDE LIGHT FIXTURE
- 400W METAL HALIDE RE-STRIKE LIGHT FIXTURE
- EXTERIOR WALL-MOUNTED LIGHT FIXTURE
- EXIT SIGN
- EMERGENCY LIGHT
- EXTERIOR MEANS OF EGRESS LIGHT FIXTURE

- CIRCUIT TAG
- RETURN AIR GRILLE
- SUPPLY AIR DIFFUSER
- LAVATORY EXHAUST FAN
- FAN MOTOR
- O.H. DOOR MOTOR
- 110V DUPLEX RECEPTACLE
- 110V QUAD RECEPTACLE
- 220V RECEPTACLE
- LIGHT SWITCH
- 3-WAY LIGHT SWITCH
- LIGHT DIMMER SWITCH
- VOICE JACK
- DATA JACK
- SPRINKLER HEAD

PLEASE NOTE:

THIS DRAWING IS DIAGRAMMATIC AND SHOULD BE USED TO DETERMINE THE DESIGN INTENT. THE CONTRACTOR SHALL FIELD VERIFY ALL WORK AND SHALL NOTIFY THE DESIGNER IMMEDIATELY OF ANY DISCREPANCIES IN THE DOCUMENTS BEFORE PROCEEDING. FAILURE TO DO SO WILL RESULT IN THE CONTRACTOR TAKING ALL RESPONSIBILITY AND LIABILITY IN SAID DISCREPANCIES.

A R Decker & Associates
Consulting Engineers
Civil - Structural
906 East Long Lake Road
Troy, Michigan 48068
Telephone (248) 528-3779
Facsimile (248) 528-3548

RICHARD BURGETT
ODESSA BUILDERS, INC.
45000 RIVER RIDGE DR.
SUITE 200
CLINTON TOWNSHIP, MI 48038
(386) 416-4500
(386) 226-5666

PROJECT TITLE
UNIT No. 3
ENTERPRISE SQUARE
20828 Hall Road
Hall Road (M-59) at Enterprise Drive
Clinton Township, MI 48038

SHEET TITLE
LIGHTING PLAN

DATE **DRAWN BY** **ISSUED FOR**
03/18/04 HJR PRELIMINARY
04/08/04 HJR REVISION

SEAL

SHEET NO.
E-1.0
PROJECT NO.
04-0134

© COPYRIGHT 2004