



200 AMP 120/240 V 1Ø 3W							
CIRC.	DESCRIPTION	BRKR.	W	CIRC.	DESCRIPTION	BRKR.	W
1				2			
3				4			
5				6			
7				8			
9				10			
11				12			
13				14			
15				16			
17				18			
19				20			
21				22			
23				24			
25				26			
27				28			
29				30			
31				32			
33				34			
35				36			
37				38			
39				40			
41				42			

SYMBOLS		LEGEND	
	RECESSED INCANDESCENT LIGHT FIXTURE		CIRCUIT TAG
	2'X4' FLUORESCENT LIGHT		RETURN AIR GRILLE
	2'X4' FLUORESCENT LIGHT W/PARABOLIC LENS		SUPPLY AIR DIFFUSER
	2'X4' FLUORESCENT NIGHT LIGHT		LAVATORY EXHAUST FAN
	2'X2' FLUORESCENT LIGHT		FAN MOTOR
	2'X2' FLUORESCENT LIGHT W/PARABOLIC LENS		O.H. DOOR MOTOR
	8'-0" TWIN-TUBE FLUORESCENT LIGHT FIXTURE		110V DUPLEX RECEPTACLE
	4'-0" TWIN-TUBE FLUORESCENT LIGHT FIXTURE		110V QUAD RECEPTACLE
	6 LAMP HI-BAY FLORESCENT LIGHT FIXTURE		220V RECEPTACLE
	400W METAL HALIDE LIGHT FIXTURE		LIGHT SWITCH
	400W METAL HALIDE RE-STRIKE LIGHT FIXTURE		3-WAY LIGHT SWITCH
	EXTERIOR WALL-MOUNTED LIGHT FIXTURE		LIGHT DIMMER SWITCH
	EXIT SIGN		VOICE JACK
	EMERGENCY LIGHT		DATA JACK
	EXTERIOR MEANS OF EGRESS LIGHT FIXTURE		SPRINKLER HEAD

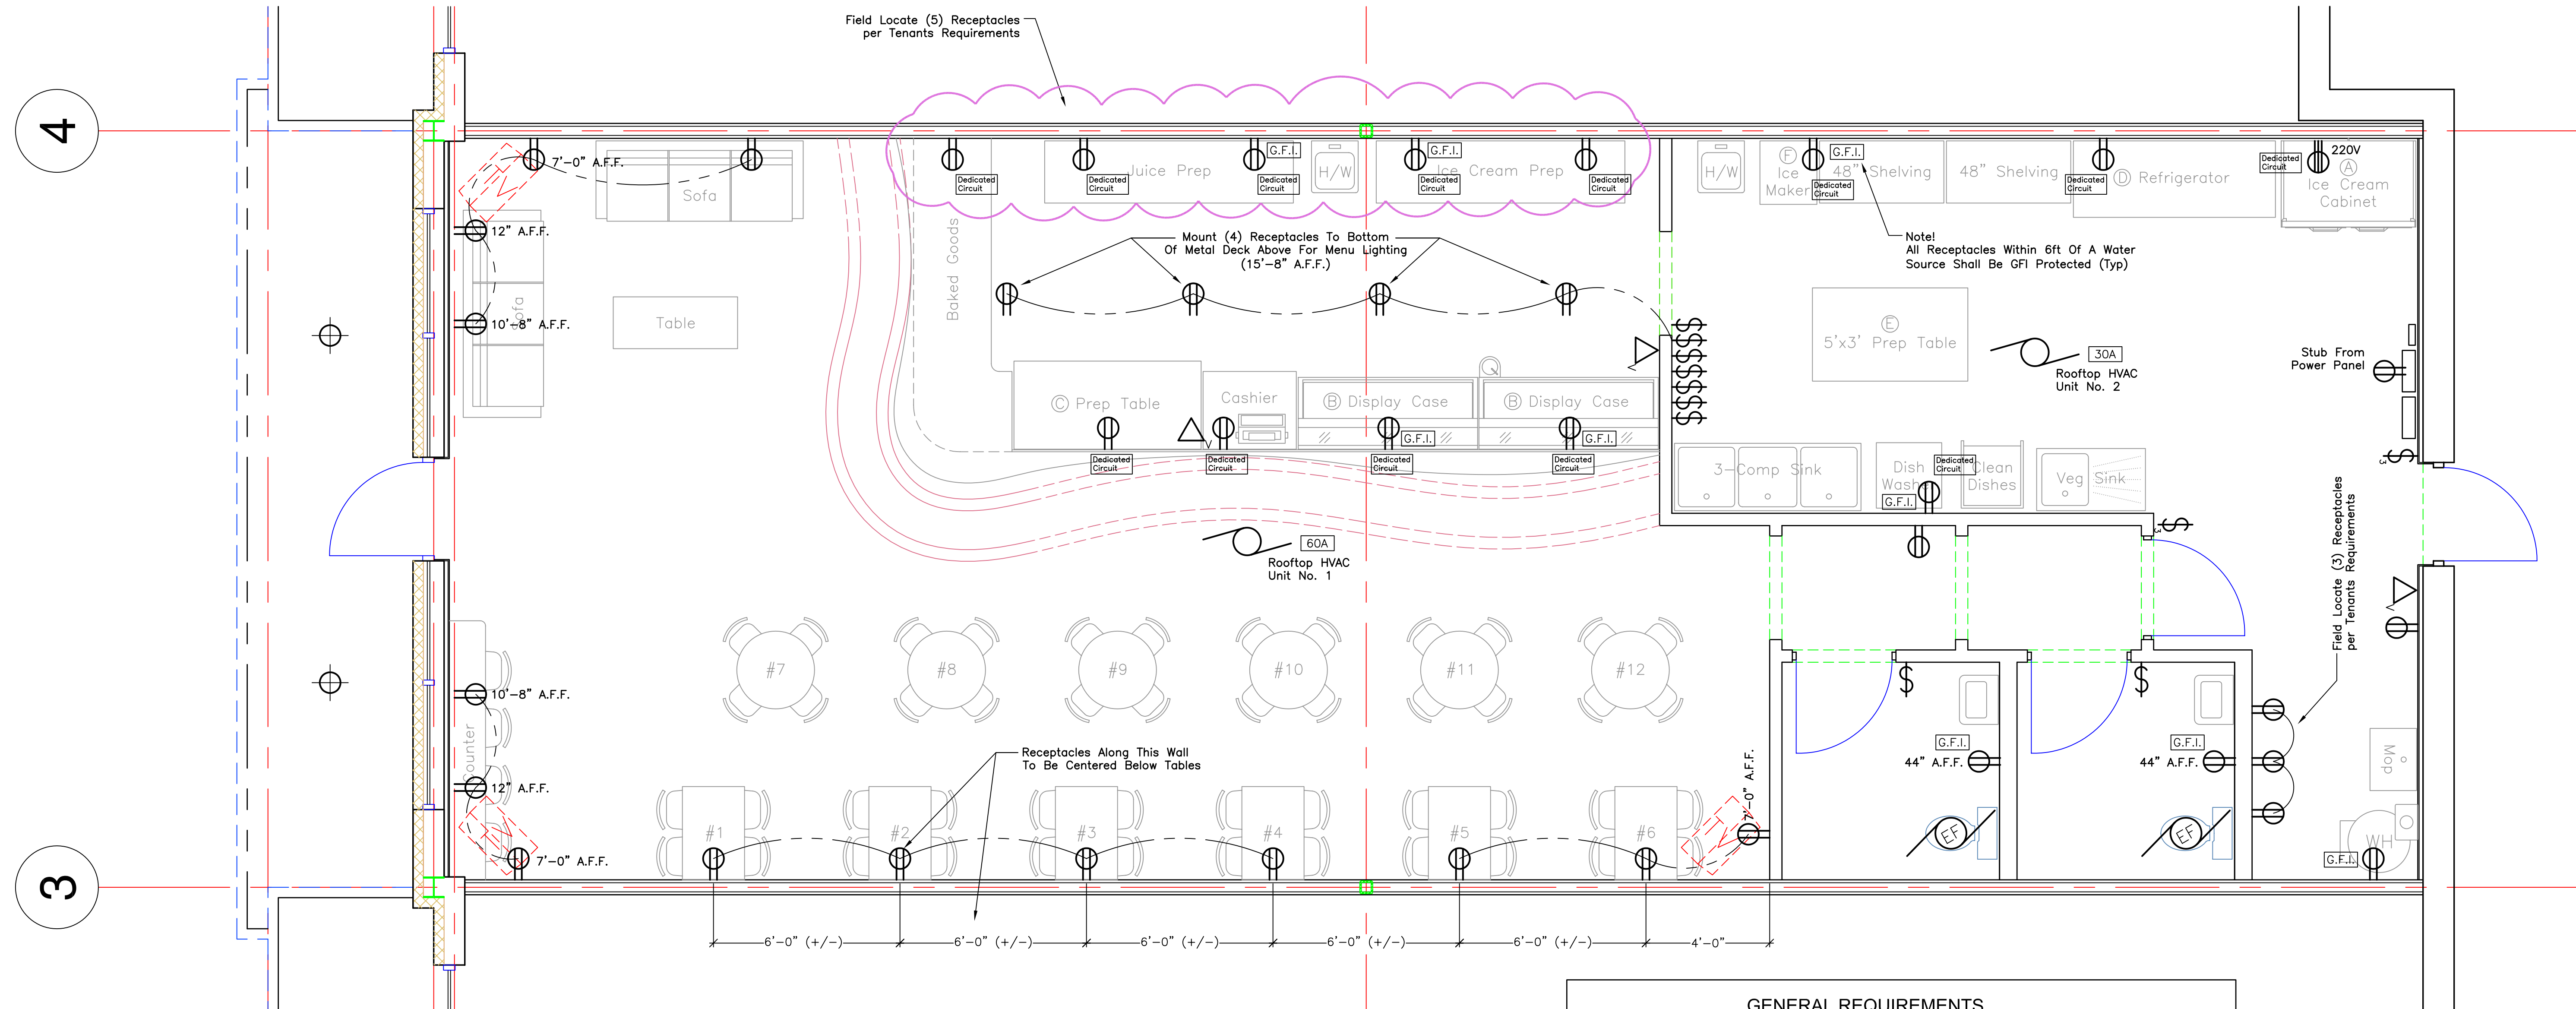

SCALE: $3/8" = 1'-0"$

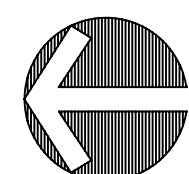

A. CODES:

1. THE WORK SHALL COMPLY WITH THE LATEST NATIONAL ELECTRIC CODE AND ALL APPLICABLE CODES AS INDICATED ON THESE DRAWINGS.

B. COORDINATION:

1. VERIFY ALL ROUGH-IN LOCATIONS, FINAL CONNECTIONS, MOUNTING HEIGHTS, VOLTAGES AND PHASES WITH OTHER TRADES EQUIPMENT SUPPLIERS SHOP DRAWINGS PRIOR TO INSTALLATION OF EQUIPMENT. FAILURE TO DO SO SHALL RESULT IN NO EXTRA CHARGES TO THE OWNER.

THIS DRAWING IS DIAGRAMMATIC AND SHOULD BE USED TO DETERMINE THE DESIGN INTENT. THE CONTRACTOR SHALL FIELD VERIFY ALL WORK AND SHALL NOTIFY THE DESIGNER IMMEDIATELY OF ANY DISCREPANCIES IN THE DOCUMENTS BEFORE PROCEEDING. FAILURE TO DO SO WILL RESULT IN THE CONTRACTOR TAKING ALL RESPONSIBILITY AND LIABILITY IN SAID DISCREPANCIES.

© COPYRIGHT 2004

A R Decker & Associates
Consulting Engineers
Civil — Structural
906 East Long Lake Road
Troy, Michigan 48098
Telephone (248) 528-3779
Facsimile (248) 528-3548

CLIENT

RICHARD BURGETT
ODESSA BUILDERS, INC.

45000 RIVER RIDGE DR.
SUITE 200
CLINTON TOWNSHIP, MI 48038
(586) 416-4500
(586) 226-5666

PROJECT TITLE
UNIT No. 3
ENTERPRISE SQUARE
20828 Hall Road
Hall Road (M-59) at Enterprise Drive
Clinton Township, MI 48038

SHEET TITLE
ELECTRICAL PLAN

DATE	DRWN BY	ISSUED FOR
03/22/04	HJR	PRELIMINARY
04/08/04	HJR	REVISION

7

SHEET NO.
E-2.0

PROJECT NO.
04-0134