


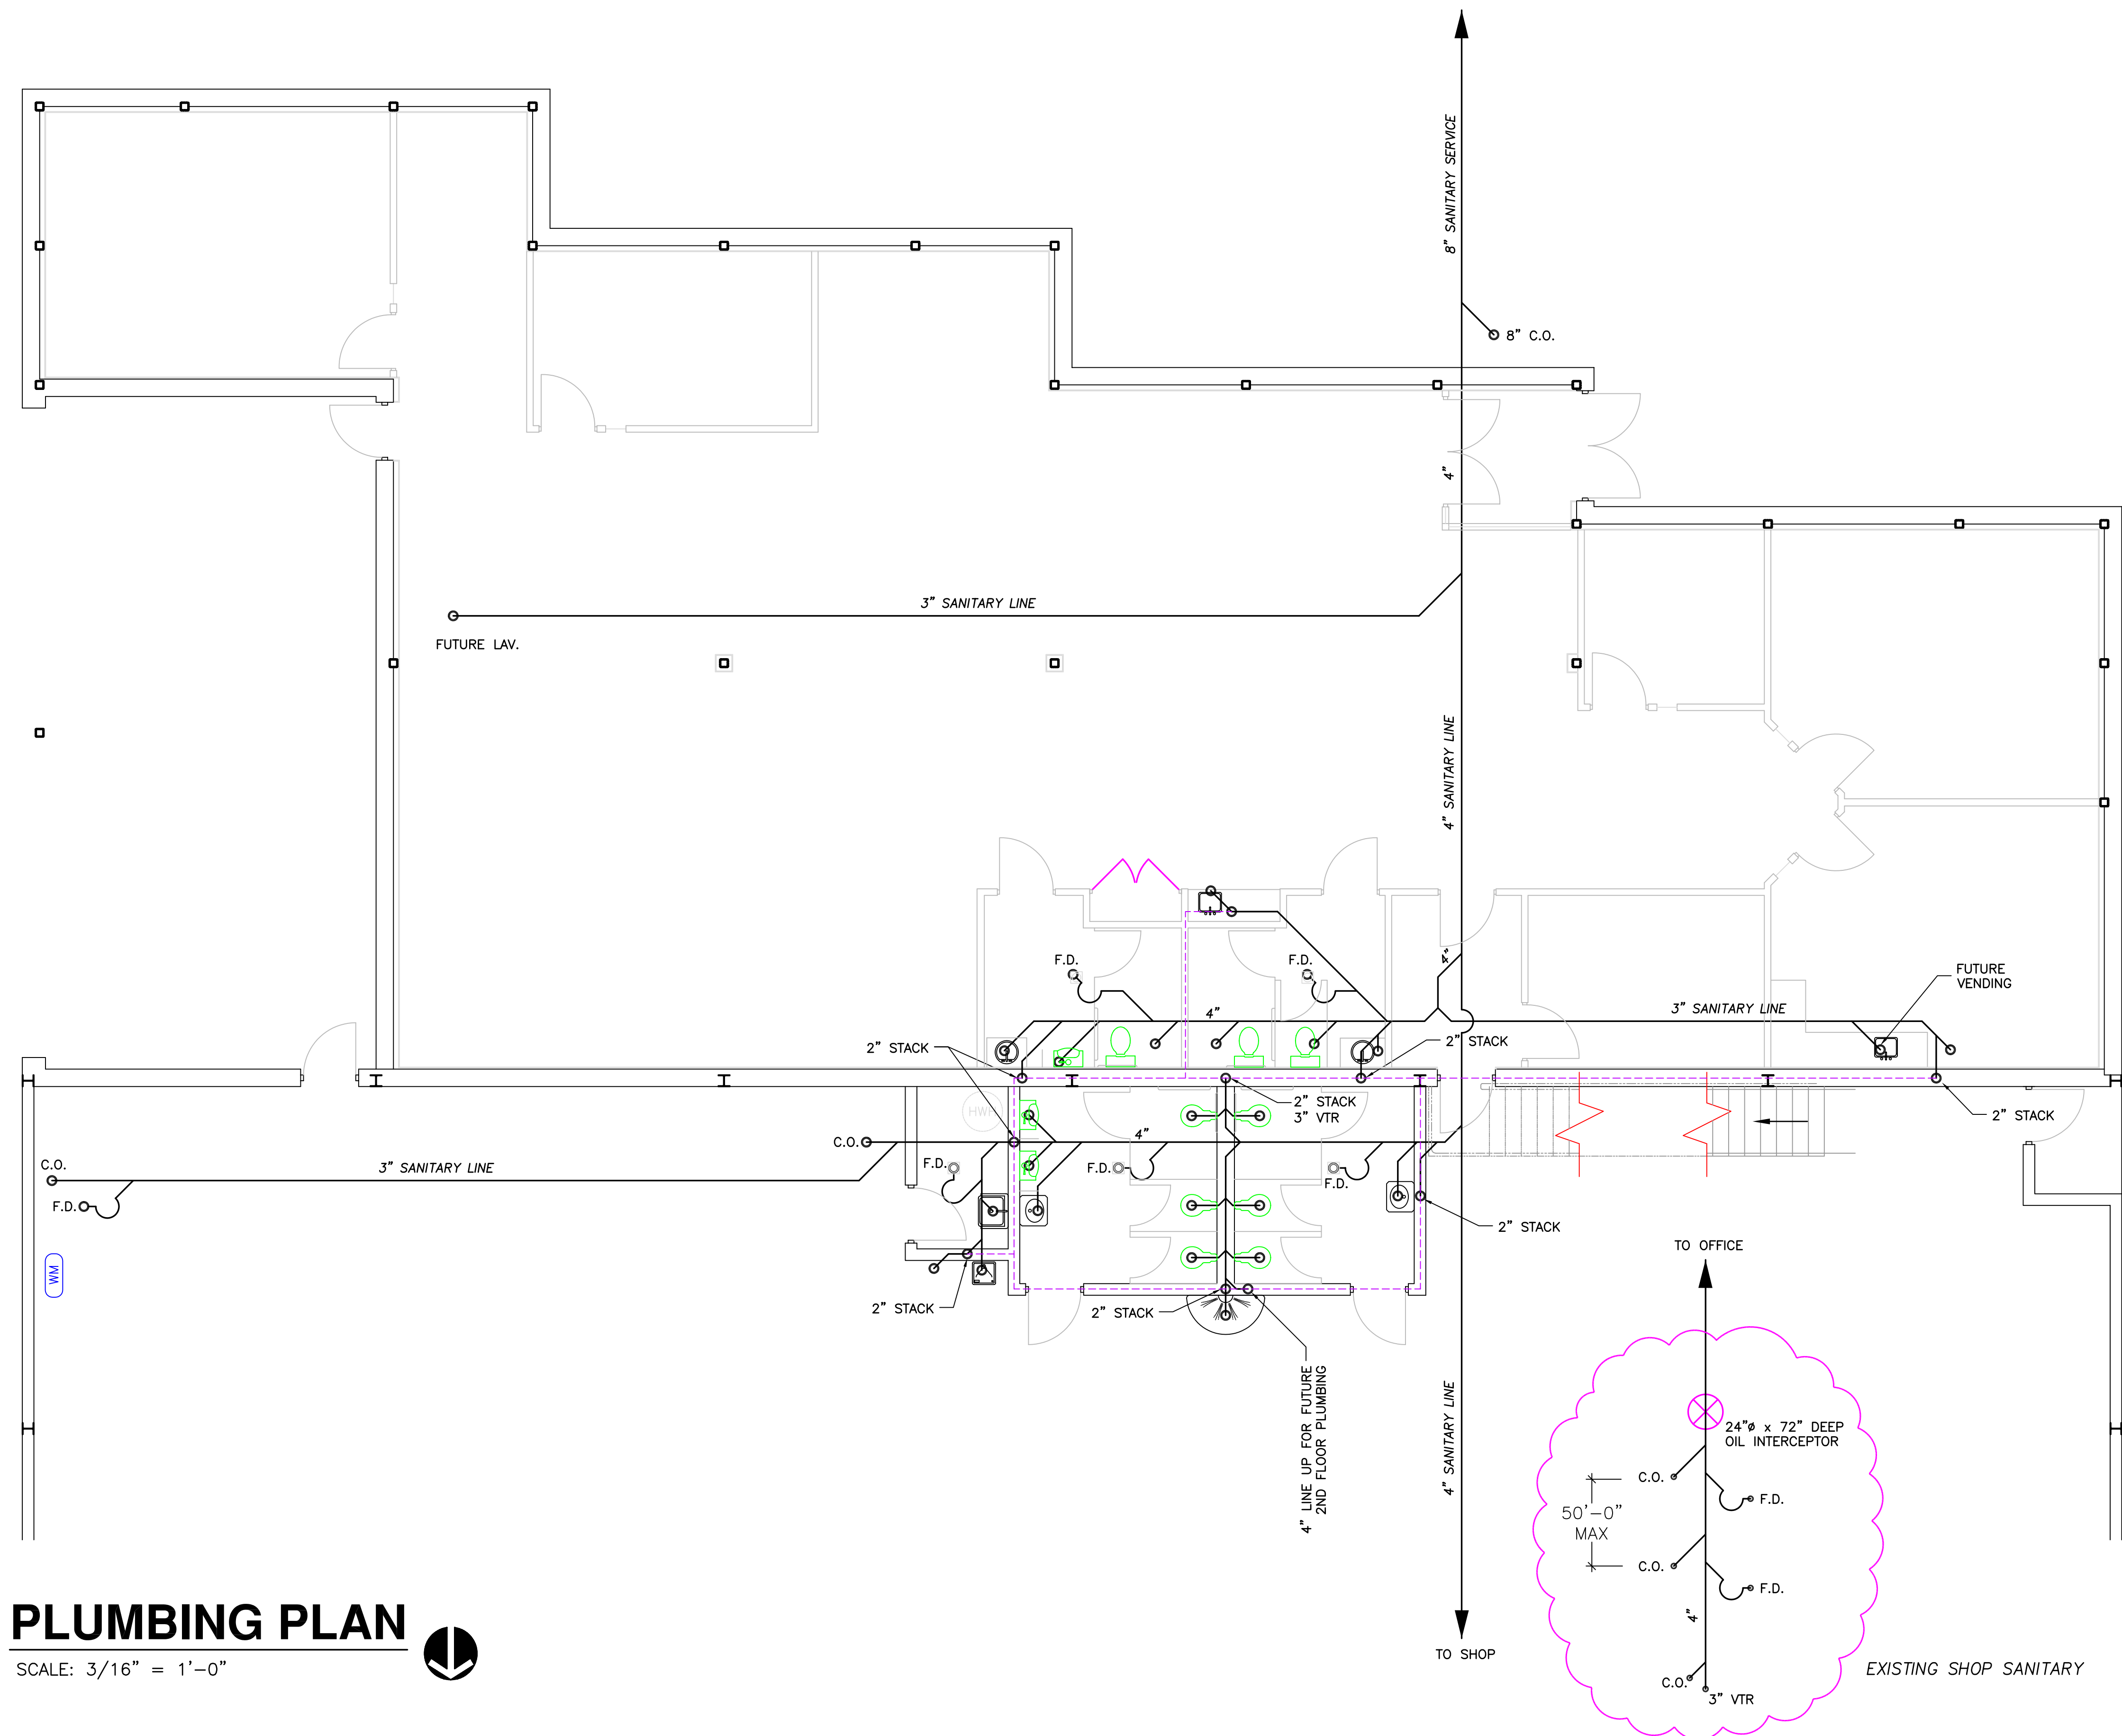

# PLUMBING PLAN

SCALE: 3/16" = 1'-0"



|                                                                                                        |  |                                                                                                                                            |                                                                                                                                                                                            |
|--------------------------------------------------------------------------------------------------------|--|--------------------------------------------------------------------------------------------------------------------------------------------|--------------------------------------------------------------------------------------------------------------------------------------------------------------------------------------------|
| PROJECT TITLE<br>POLYMER PROCESS DEVELOPMENT<br>LOT #2<br>24201 CAPITOL BLVD<br>CLINTON TWP., MI 48046 |  | CLIENT<br>R. BURGETT<br>ODESSA BUILDERS<br>45000 RIVER RIDGE DR<br>RIVER RIDGE CORPORATE CENTRE<br>CLINTON TWP, MI 48038<br>(810) 416-4500 | CLIENT<br>A R Decker & Associates<br>Consulting Engineers<br>Civil — Structural<br>906 East Long Lake Road<br>Troy, Michigan 48098<br>Telephone (248) 528-3779<br>Facsimile (248) 528-3548 |
| SHEET TITLE<br>PLUMBING PLAN                                                                           |  | DATE<br>03/13/20<br>4/18/01                                                                                                                |                                                                                                                                                                                            |
| DRWN BY<br>JAK<br>HR                                                                                   |  | ISSUED FOR<br>PLUMBING PERMIT<br>OFFICE AREA BUILD-OUT                                                                                     |                                                                                                                                                                                            |
| SHEET NO.<br>P-1                                                                                       |  | PROJECT NO.<br>97342                                                                                                                       |                                                                                                                                                                                            |